


**BASED ON 30 PERSON @ 10 l/s  
OCCUPATION (PEAK DEMAND)**

- NOTES :**
- **DO NOT SCALE: CONTRACTOR TO CHECK ALL DIMENSIONS AND REPORT ANY OMISSIONS OR ERRORS**
  - **ALL DIMENSIONS ARE IN MILLIMETRES, UNLESS NOTED OTHERWISE**
  - **THIS DRAWING IS NOT FOR INSTALLATION PURPOSES. DESIGN, INSTALLATION AND CO-ORDINATION DRAWINGS SHALL BE PROVIDED BY THE CONTRACTOR IN ACCORDANCE WITH THE SPECIFICATION. THE CONTRACTOR IS TO READ THIS DRAWING IN CONJUNCTION WITH THE HEALTH AND SAFETY PLAN AND DESIGN HAZARD INFORMATION.**

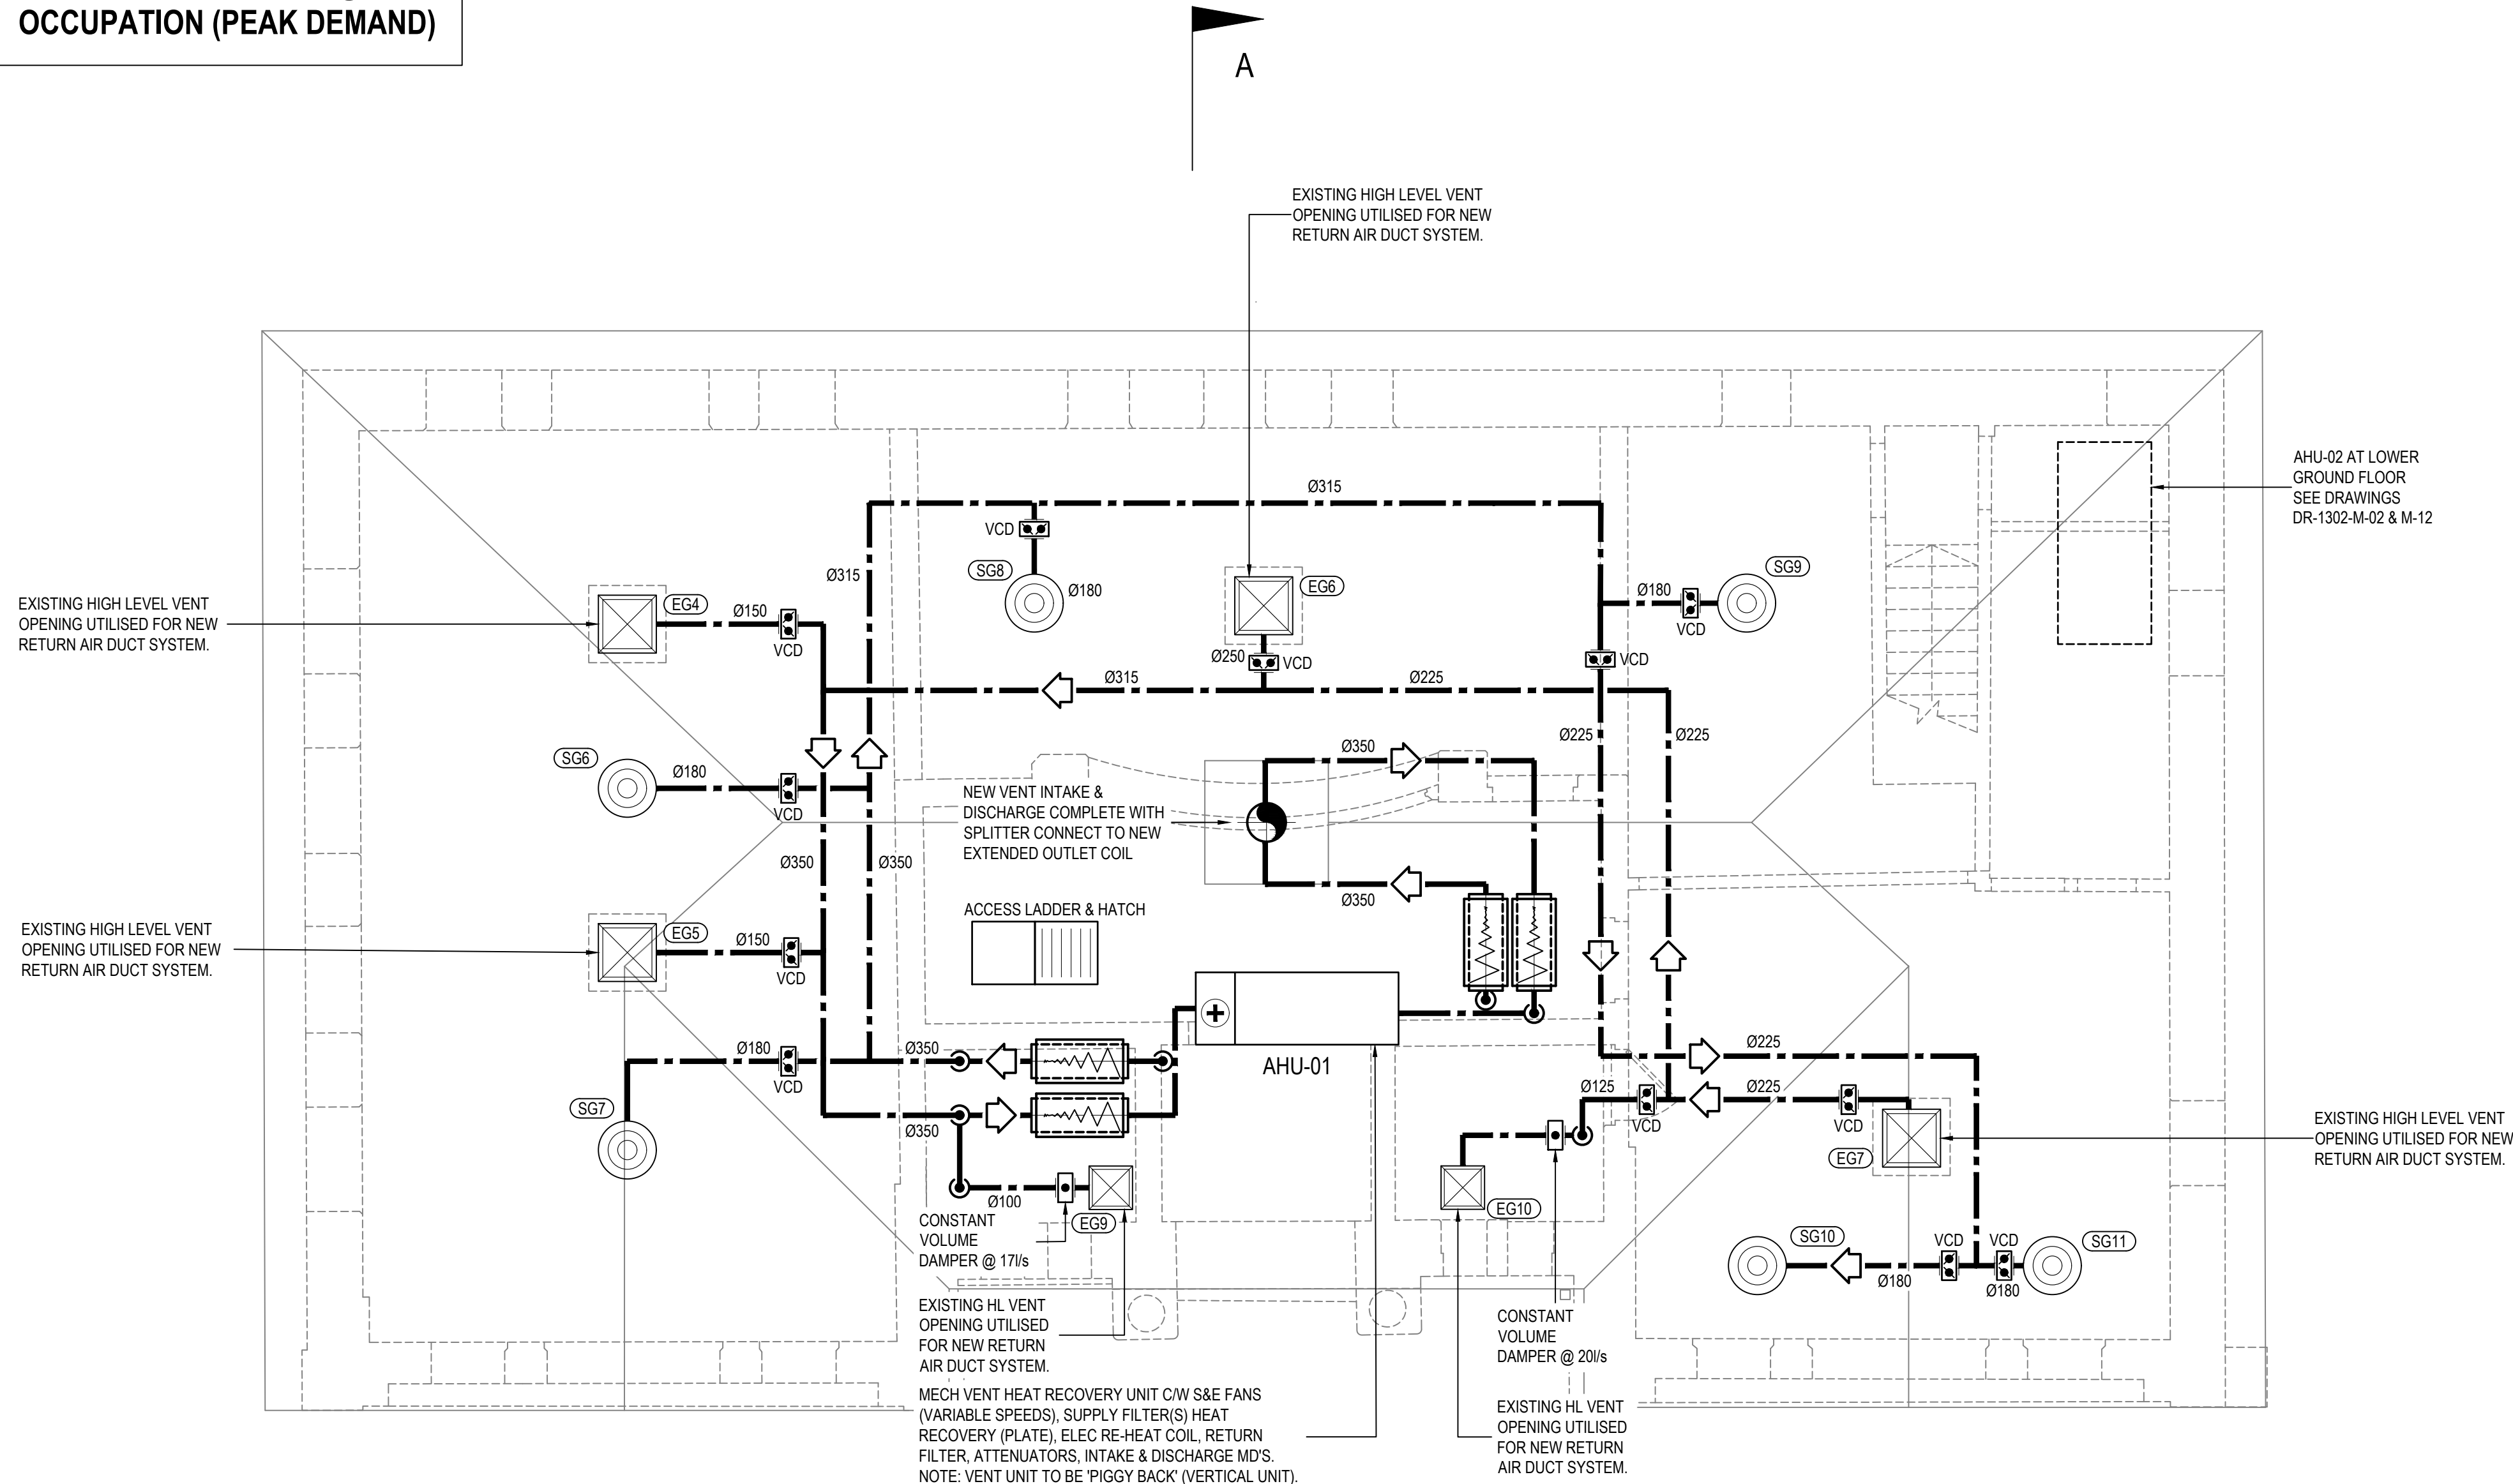

SEE DRAWING DR-1302-M-02  
FOR GRILLE SCHEDULES  
WITH AIR VOLUMES

## TENDER ISSUE

|     |              |     |     |          |
|-----|--------------|-----|-----|----------|
| T1  | TENDER ISSUE | KS  | RW  | 02.05.23 |
| T0  | TENDER ISSUE | KS  | RW  | 28.04.23 |
| REV | DESCRIPTION  | CHK | APP | DATE     |

Client:

MERTHYR TYDFIL COUNTY  
BOROUGH COUNCIL  
CIVIC CENTRE, CASTLE STREET,  
MERTHYR TYDFIL, CF47 8AN



4 Ty Nant Court,  
Morganstown,  
Cardiff,  
CF15 8LW



T: 02920 811266  
F: 02920 814459  
W: [www.draccor.co.uk](http://www.draccor.co.uk)

---


Project:

TREHARRIS LIBRARY


Drawing Title:  
PROPOSED ROOF LEVEL  
VENTILATION LAYOUT

|                                 |               |                 |                  |                    |
|---------------------------------|---------------|-----------------|------------------|--------------------|
| Scale @ A1<br>1:50              | Drawn<br>M.P. | Checked<br>K.S. | Approved<br>R.W. | Date<br>28.04.23   |
| Drawing No.<br><br>DR-1302-M-03 |               |                 |                  | Revision<br><br>T1 |

© DRAC Consulting

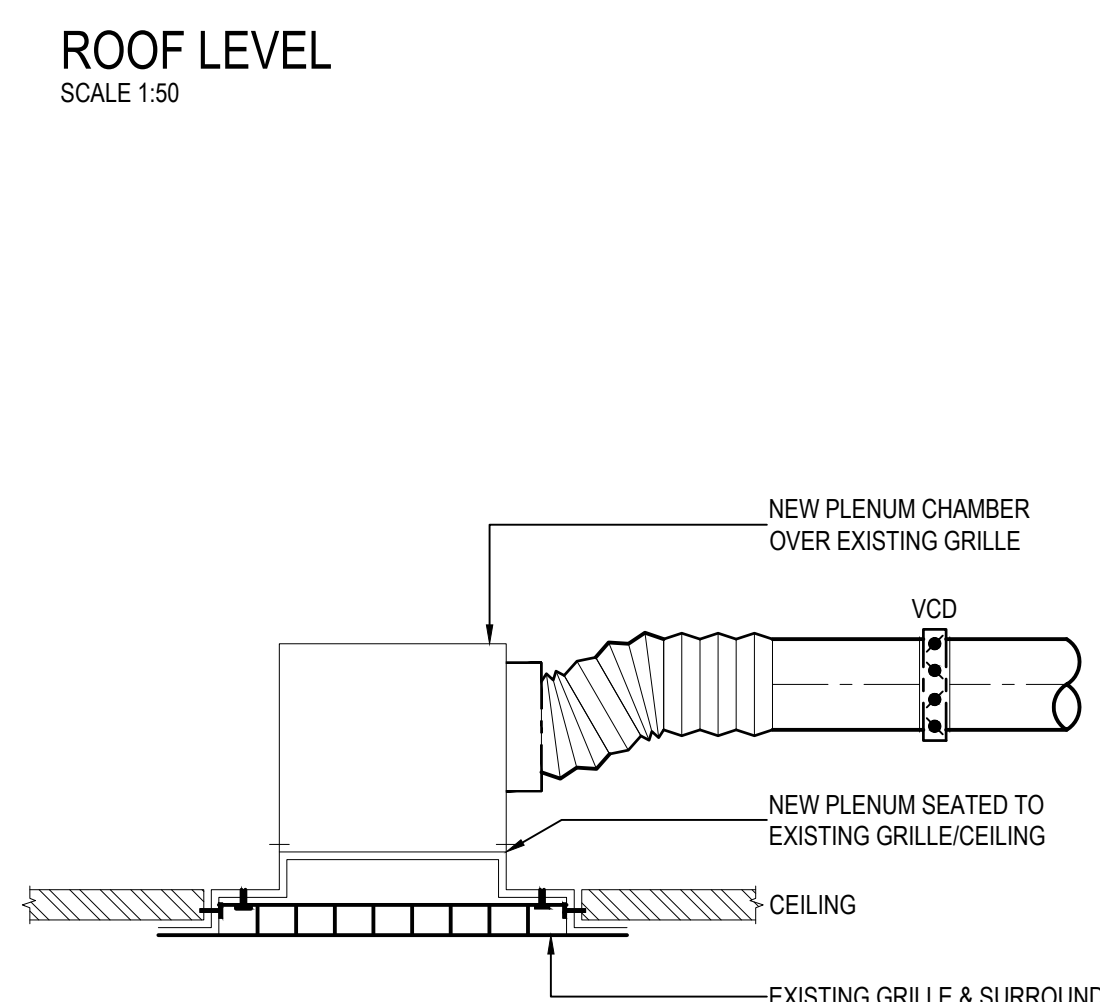

TYPICAL EXISTING EXTRACT SECTION  
NOT TO SCALE

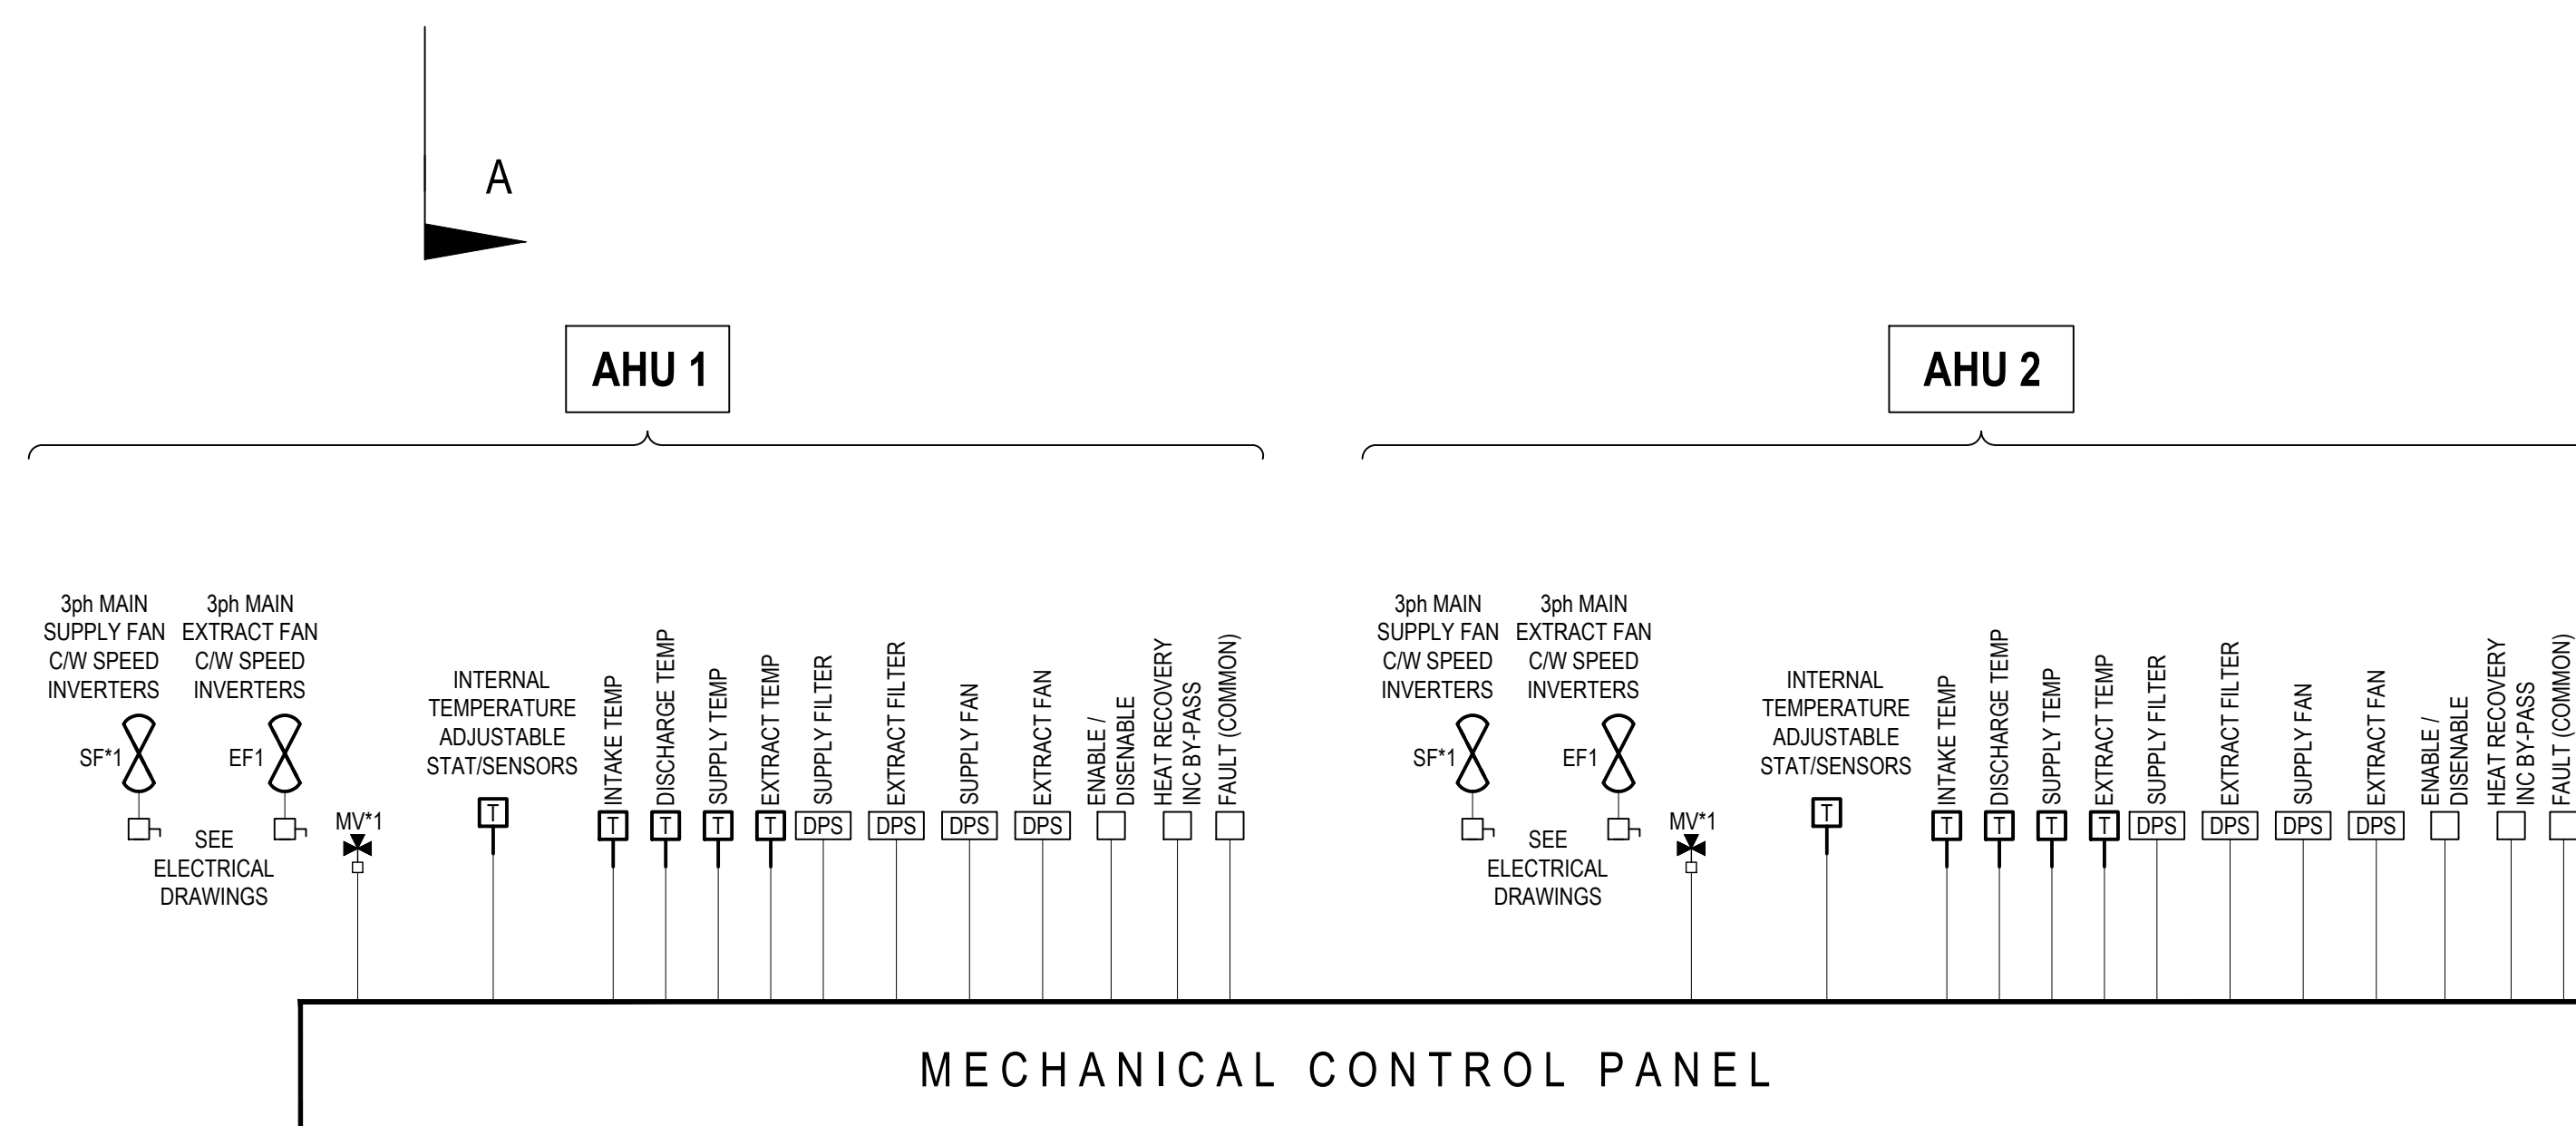

0 500 1000 1500 2000 2500mm  
SCALE 1:50 @ A1: 1:100 @ A3