



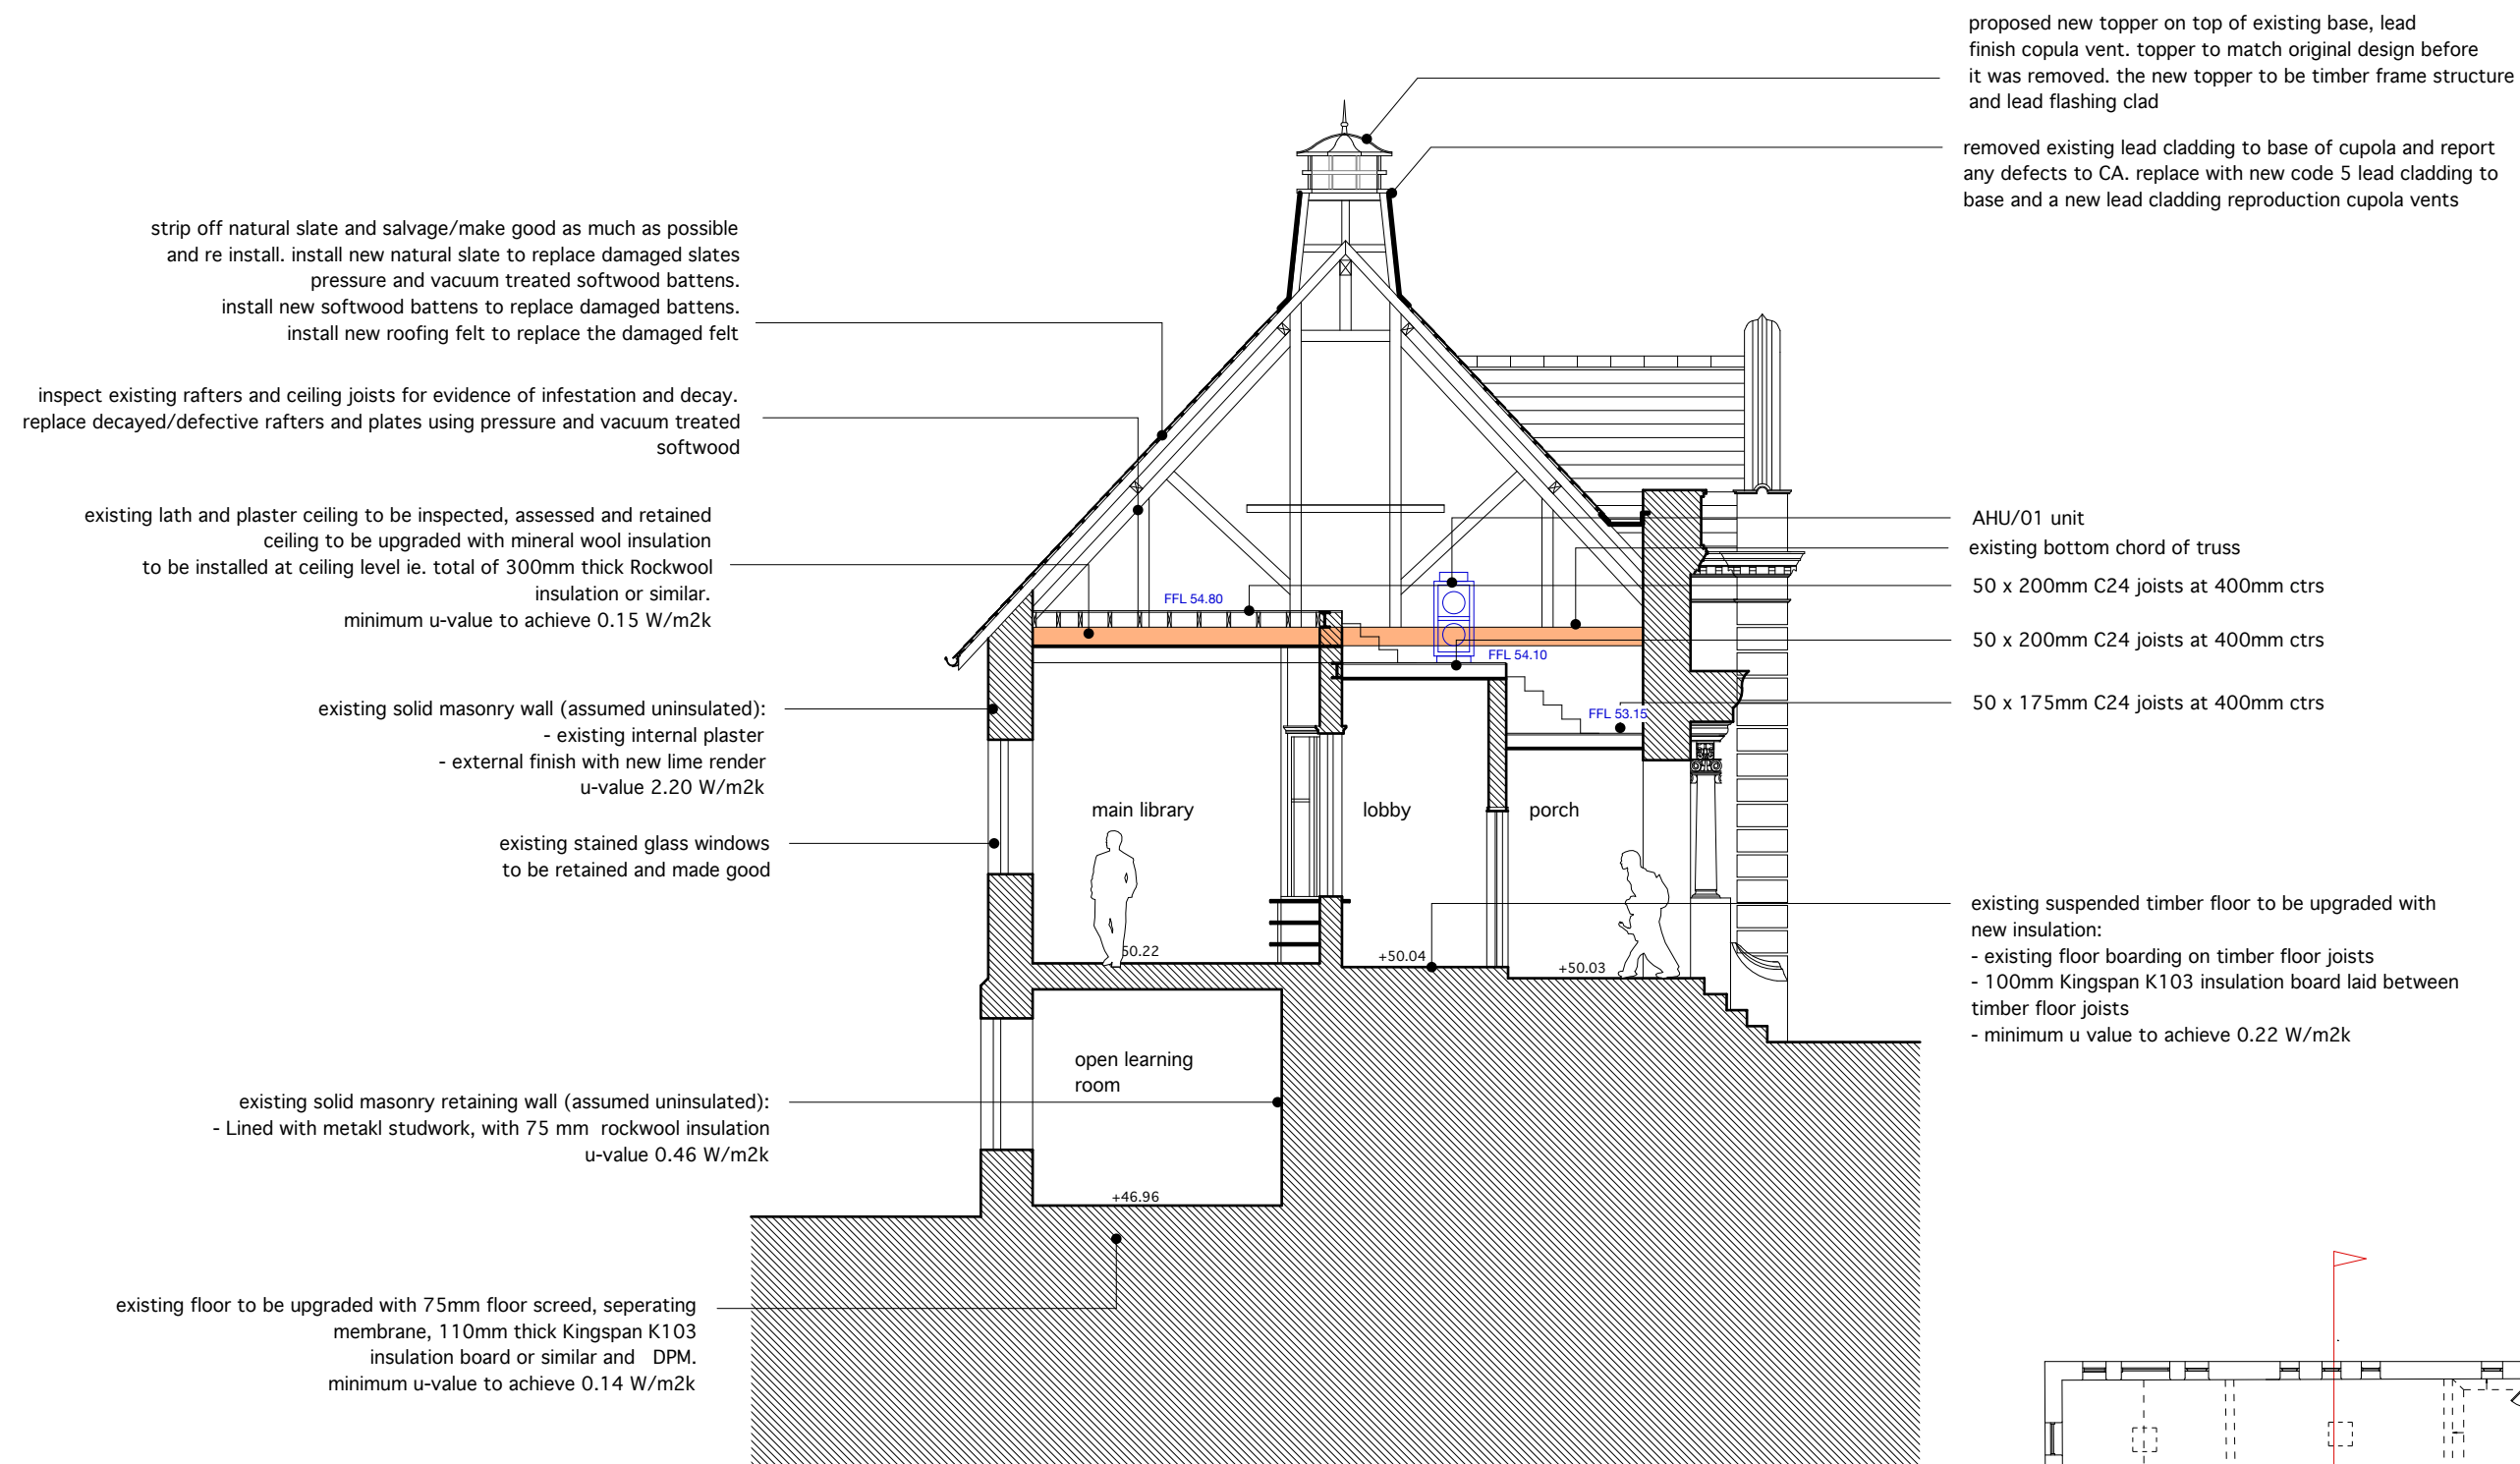

notes:
1. for proposed ventilation layout to section drawing, refer to M&E consultant engineer drawing no. DR-1302-M-04

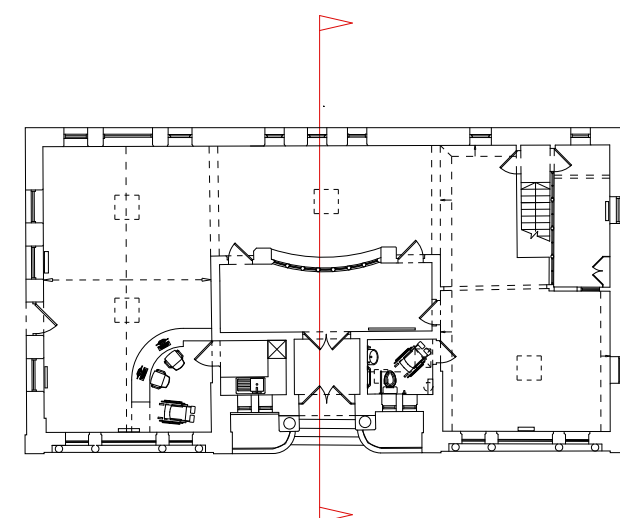

Treharris Library

proposed section 01

1:100 @ A3

E	12.06.23	attic space updated to align with engineer drawing
D	02.06.23	drawings updated. email on 02.06.23
C	26.05.23	ceiling joists updated
B	31.03.23	section updated
A	11.01.23	u value info added
Rev	Date:	Action:
This drawing is copyright.		
Dimensions to be checked on site and any discrepancies reported to the Architect immediately .		
Do not scale, use figured dimensions only.		

Merthyr Tydfil CBC

Treharris Library

Proposed Section 01

1:100 @ A3

2217 - 003

E

6 north road, cardiff. cf10 3du

029 2034 0491

www.cfw-architects.co.uk