



FILENAME : E:\PROJECTS\DR-1302 TREHARRIS LIBRARY AND CAEDRAW EXTENSIONS\ON02 CAD\MEP\MECHANICAL\NEW\DR-1302-M-01 (T1).EXISTING LGE & GF HEATING & VENTILATION LAYOUT.DWG | PLOTTED BY : MOHAMMAD GHASEMDOLU | PLOTTED DATE : 02 May 2023 12:03:14


- NOTES :
- DO NOT SCALE: CONTRACTOR TO CHECK ALL DIMENSIONS AND REPORT ANY OMISSIONS OR ERRORS
 - ALL DIMENSIONS ARE IN MILLIMETRES, UNLESS NOTED OTHERWISE
 - THIS DRAWING IS NOT FOR INSTALLATION PURPOSES. DESIGN, INSTALLATION AND CO-ORDINATION DRAWINGS SHALL BE PROVIDED BY THE CONTRACTOR IN ACCORDANCE WITH THE SPECIFICATION. THE CONTRACTOR IS TO READ THIS DRAWING IN CONJUNCTION WITH THE HEALTH AND SAFETY PLAN AND DESIGN HAZARD INFORMATION.

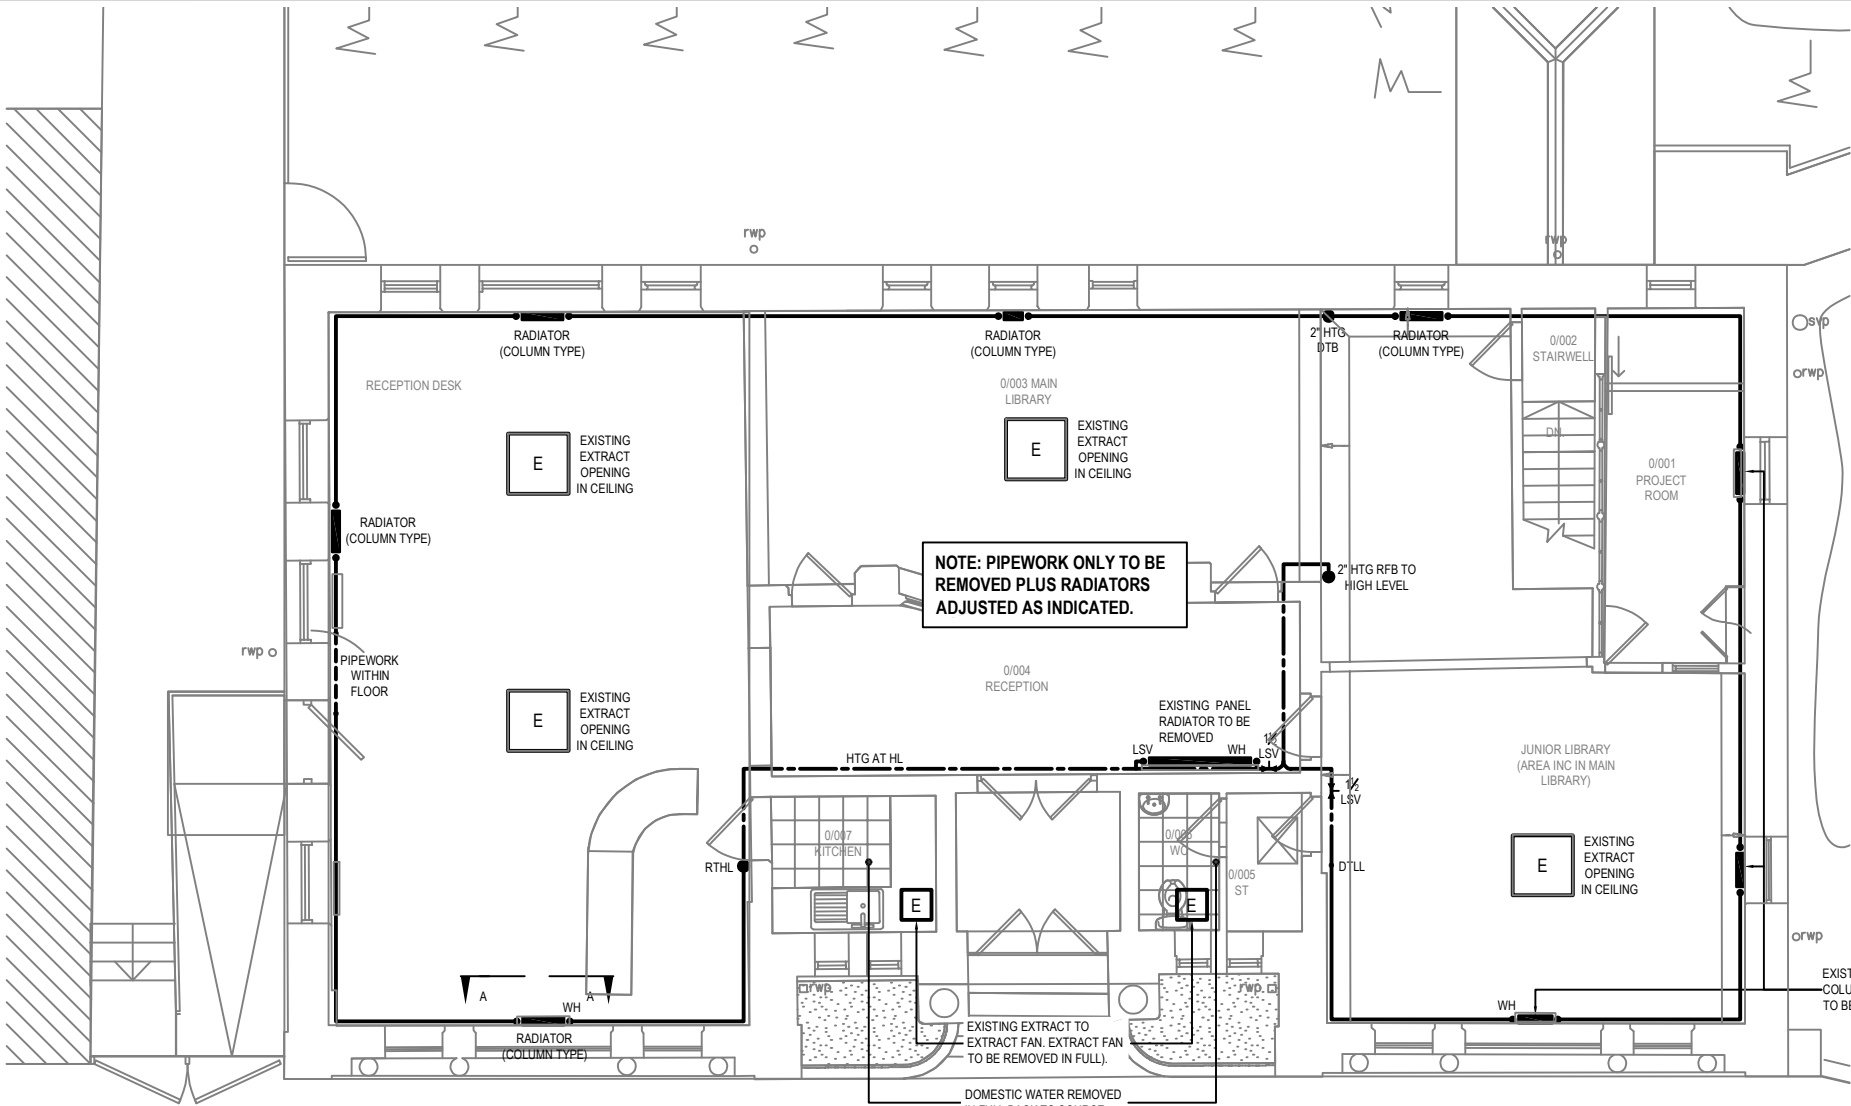


GROUND FLOOR
SCALE 1:50

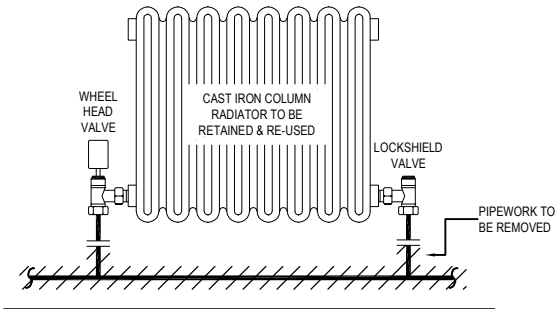

ELEVATION A-A
NOT TO SCALE

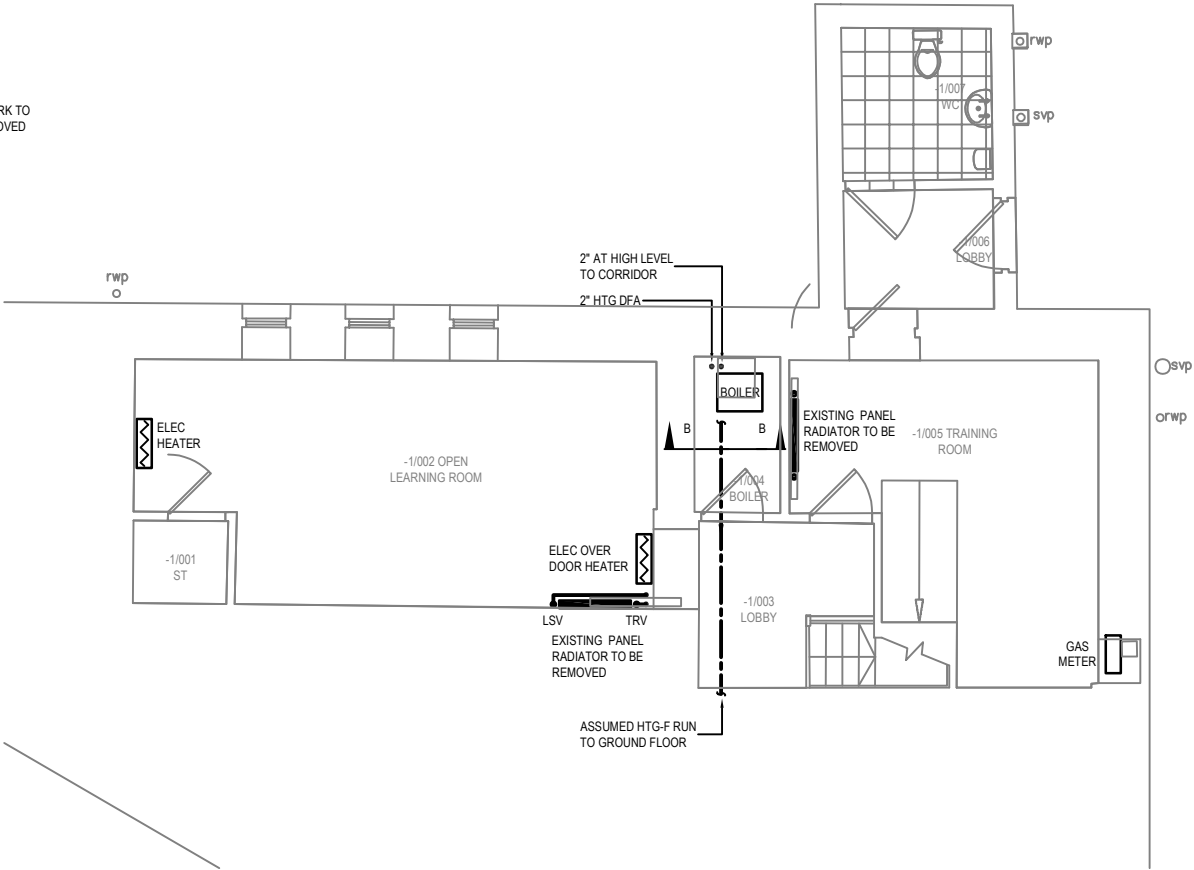

LOWER GROUND FLOOR

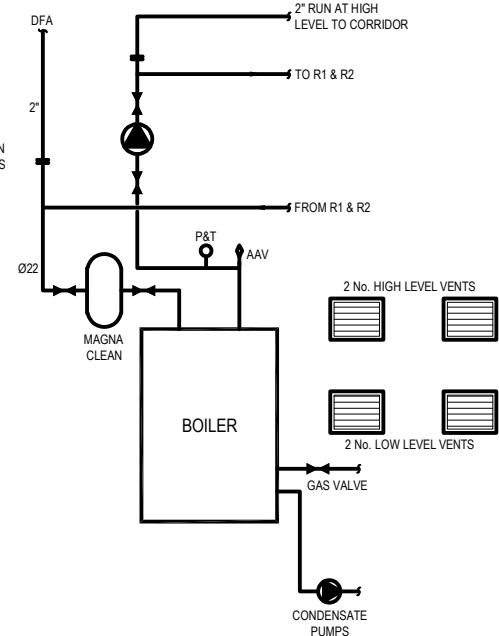

ELEVATION B-B
NOT TO SCALE
(TO BE REMOVED IN FULL BACK TO METER)

TENDER ISSUE

T1	TENDER ISSUE	KS	RW	02.05.23
T0	TENDER ISSUE	KS	RW	28.04.23
REV	DESCRIPTION	CHK	APP	DATE

Client:

MERTHYR TYDFIL COUNTY
BOROUGH COUNCIL
CIVIC CENTRE, CASTLE STREET,
MERTHYR TYDFIL, CF47 8AN



4 Ty Nant Court,
Morganstown,
Cardiff,
CF15 8LW



T: 02920 811266
F: 02920 814459
W: www.dracconsulting.com

Project:

TREHARRIS LIBRARY

Drawing Title:

EXISTING
LOWER GROUND FLOOR & GROUND FLOOR
HEATING & VENTILATION LAYOUT

Scale @ 1:50	Drawn M.P.	Checked K.S.	Approved R.W.	Date 28.04.23
Drawing No.	DR-1302-M-01	Revision T1		