


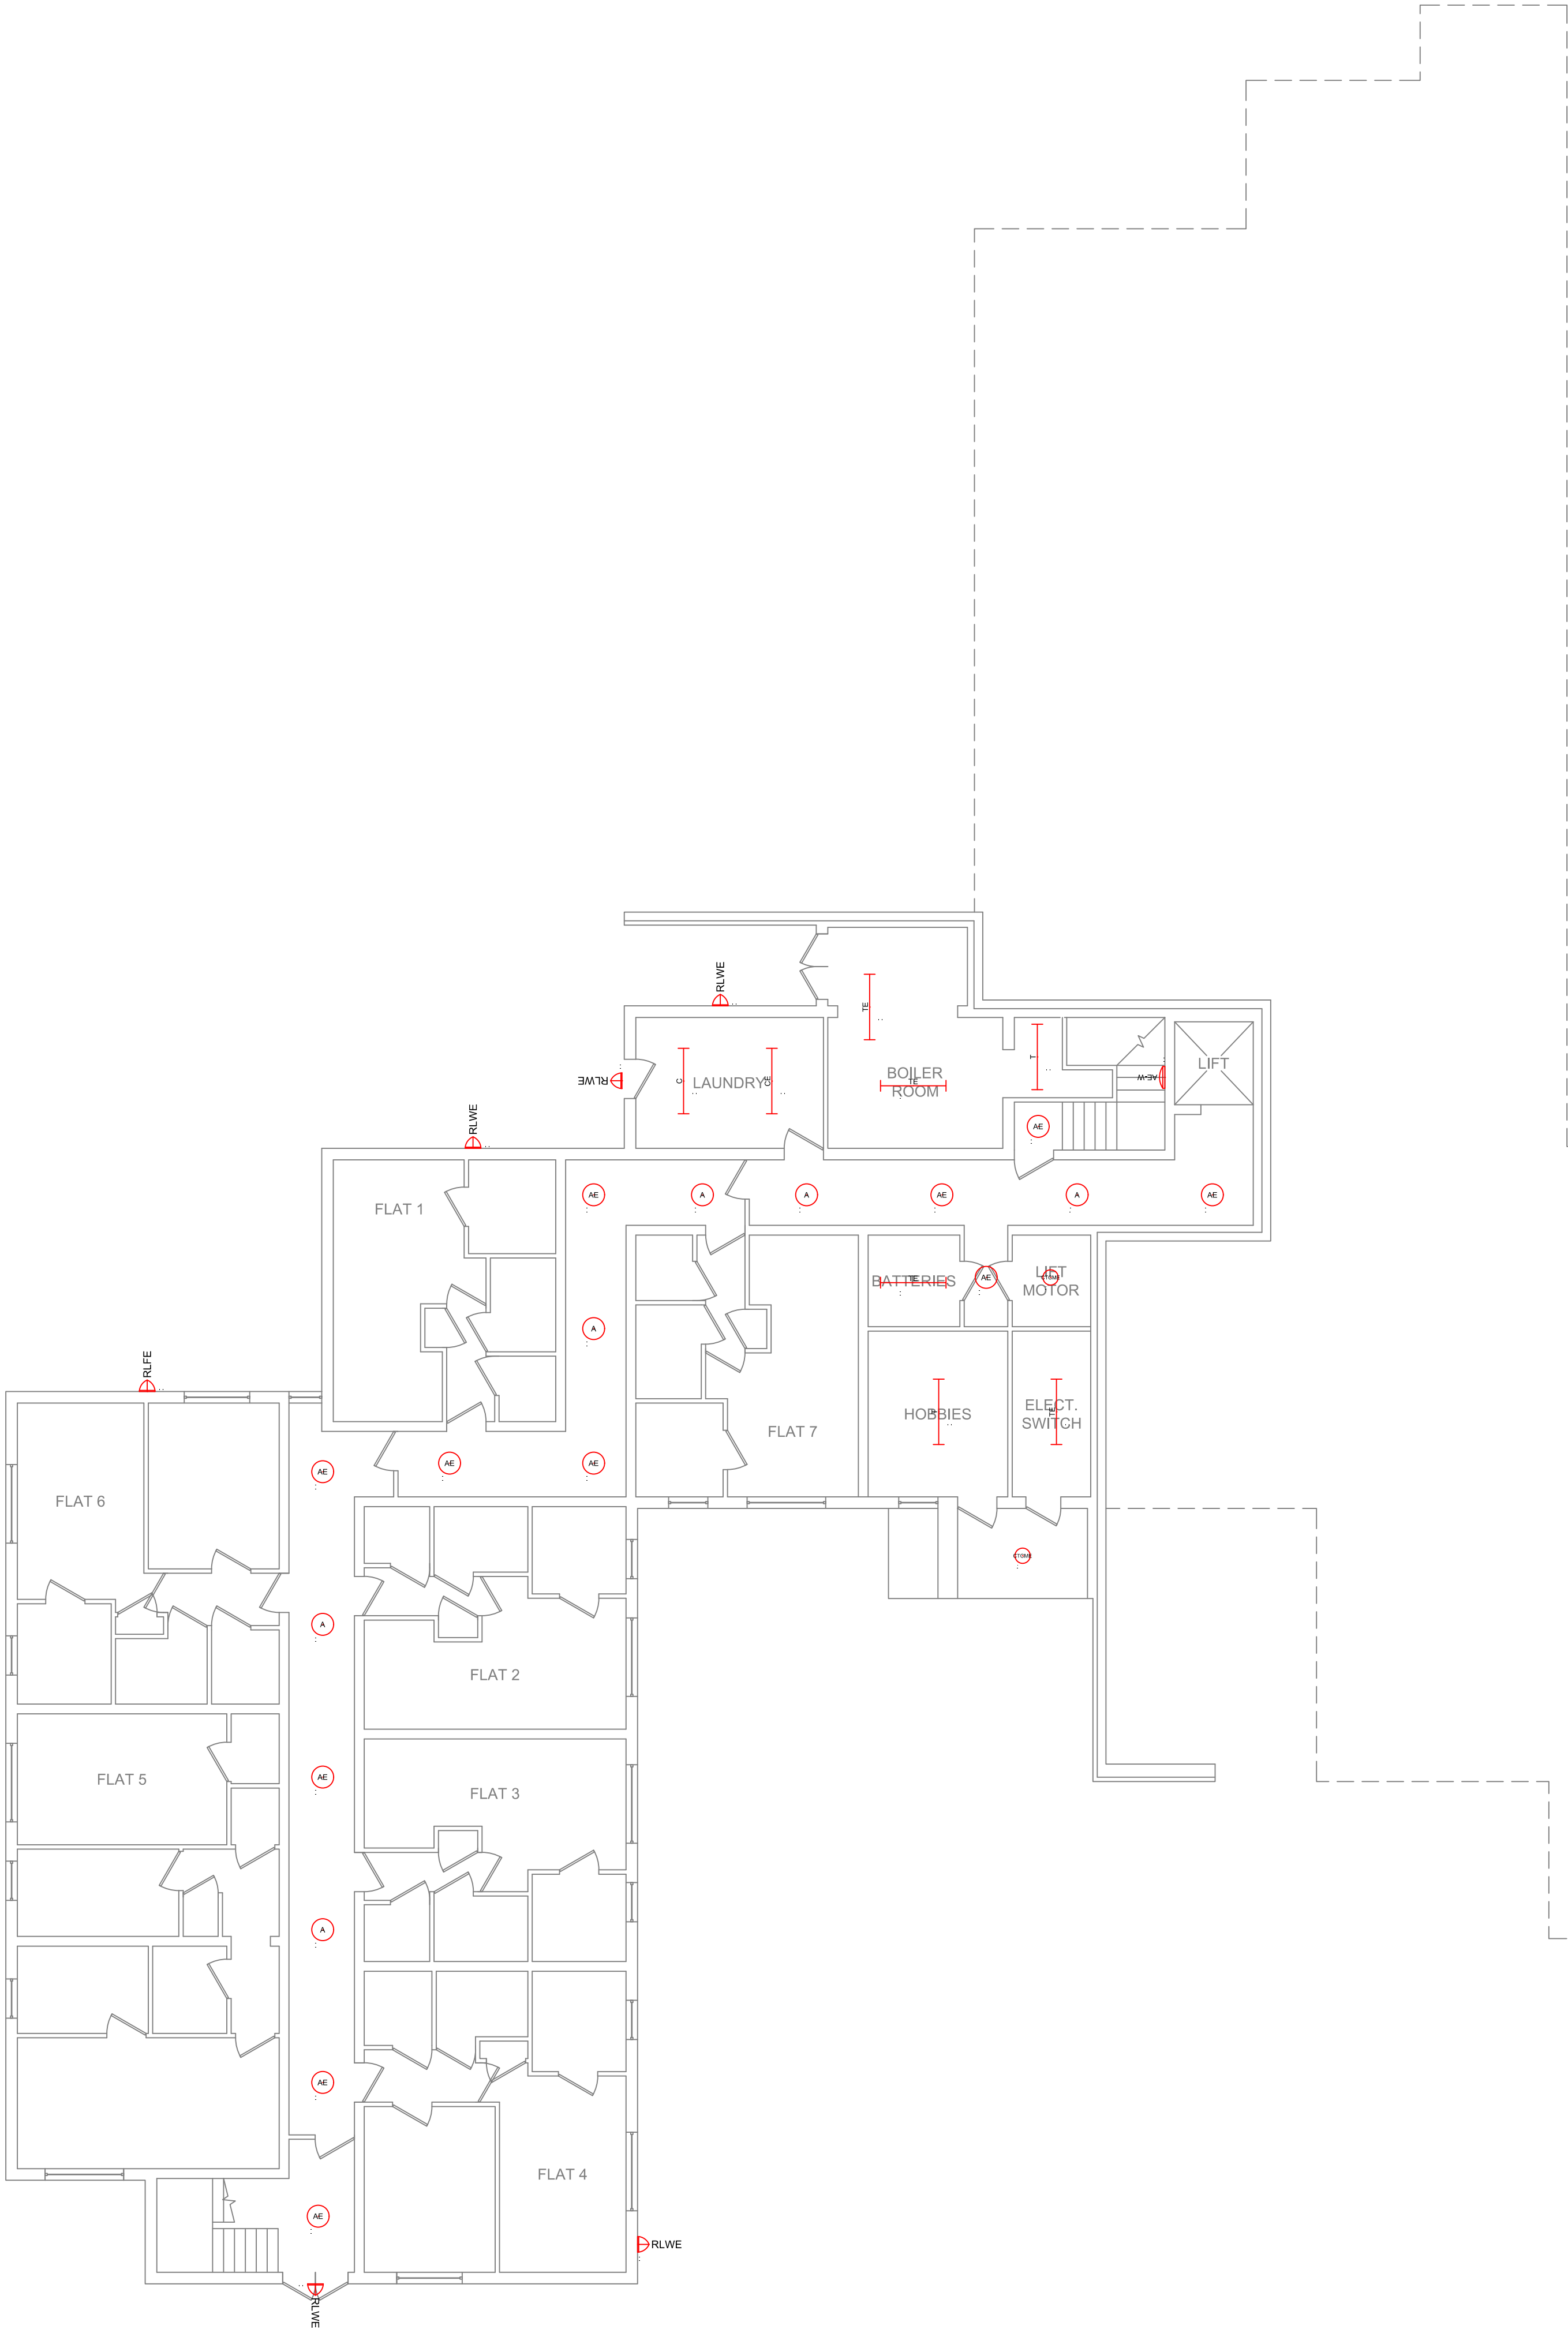

THORLUX KEY

	6	DOT16490SS 17w LED circular DOT SmartScan luminaire. Satin sparkle Version.
	11	WDT16490SS 17w LED circular DOT SmartScan luminaire. SmartScan Emergency. Satin Sparkle Version.
	1	WDT16490SS 17w LED circular DOT SmartScan luminaire. SmartScan Emergency. Satin Sparkle Version. Wall mounted
	0	JUB16694SS 30w LED 1500mm Jubilee XL luminaire. SmartScan.
	0	WJB16694SS 30w LED 1500mm Jubilee XL luminaire. SmartScan. SmartScan emergency Version.
	1	KB16108SS 37w LED Kanby LED Controller luminaire. SmartScan.
	1	WKB16108SS 37w LED Kanby LED Controller luminaire. SmartScan. SmartScan Emergency Version.
	0	CT16174SS 16w LED Cobalt SmartScan luminaire.
	2	WCT16174SS 16w LED Cobalt SmartScan luminaire. SmartScan Emergency version.
	0	CT15814SS 16W Cobalt. SmartScan. Satin
	0	WCT15814SS 16W Cobalt. SmartScan. Satin. SmartScan Emergency
	0	GLO16484LF 20w LED Glodome circular luminaire. Non-dimming
	0	DOT16499LF 17w LED circular DOT luminaire. Opal Version.
	0	RL19111SS 34w LED 4000K Realta high performance SmartScan exterior luminaire. Polycarbonate Cover. Area Distribution
	1	WRL19111SS 34w LED 4000K Realta high performance SmartScan exterior SmartScan emergency luminaire. Polycarbonate Cover. Area Distribution
	0	RL19069SS 8w LED Realta SmartScan polycarbonate refractor LED high performance exterior luminaire. Wide Distribution. 4000K.
	5	WRL19069SS 8w LED Realta SmartScan polycarbonate refractor LED high performance exterior luminaire. Wide Distribution. SmartScan Emergency Version. 4000K.
	2	TP19773SS 30w LED 1500mm Thoroproof SmartScan anti-corrosive luminaire. IP54.
	4	WTP19773SS 30w LED 1500mm Thoroproof SmartScan anti-corrosive luminaire. IP54. SmartScan Emergency
	0	SS20213 SmartScan Touch wall plate - mains

REV.	DATE	BY	DESCRIPTION
Notes			
1.	This drawing is for schematic purposes and installation shall fully comply with BS7671 (or National equivalent).		
2.	Luminaire positions are indicative only and subject to confirmation of ceiling types. Ceiling voids and other obstructions not taken into consideration unless shown on the layout.		
3.	Lighting designs will be carried out in accordance with information provided. Where no information is provided, lighting design criteria will be selected in accordance with the minimum required values as detailed within guidance provided by CIBSE/SLL or British/Irish Standards. Thorlux will not be held responsible if inaccurate, incomplete or out of date information is provided.		
4.	It is the installing contractors responsibility to ensure all luminaires and lighting controls are suitable for the environment and ceiling type for which they are proposed.		
5.	In designing this initial scheme we have prejudged areas which are likely to require emergency lighting in compliance with BS5266-1, -7 & -8 but it is the customer's responsibility to risk assess all areas, ensure coverage of all "positions of emphasis" and notify changes. Consequently, our design is limited pending this information.		
6.	When required, interconnecting leads and mains starter leads have been included. Horizontal distance between luminaires has been used to determine the length of interconnecting leads. Additional leads to be ordered separately if required, for example, to allow for unforeseen obstructions within the ceiling void.		
7.	PIR positions are indicative only and are subject to quantity and location changes dependant upon room and furniture layouts.		
8.	The provided Lighting Design has been completed by others and Thorlux Lighting accept no design responsibility relating to this scheme.		

The proposed lighting scheme is subject to our terms and conditions which can be found here: <http://www.thorlux.com/terms>



Merse Road, North Moons Moat,
Redditch, Worcestershire
B98 9HH.
Telephone 01527 583200
Facsimile 01527 584177
E-Mail lighting.design@thorlux.co.uk
Web site: www.thorlux.com

 
 
 
 
PROPOSED LIGHTING LAYOUT

Ty Brynseion
Lower Ground Floor

SCALE	1:100 @ A1
DATE	06/09/2022
DRN. BY	EP
DESIGNER	GM

DRAWING No.	
558330-00	
BASED ON CUSTOMER DRG. ORIGINATOR:	REV. DATE



	18	DOT16490SS 17w LED circular DOT SmartScan luminaire. Satin sparkle Version.
	30	WDT16490SS 17w LED circular DOT SmartScan luminaire. SmartScan Emergency. Satin Sparkle Version.
	3	WDT16490SS 17w LED circular DOT SmartScan luminaire. SmartScan Emergency. Satin Sparkle Version. Wall mounted
	0	JUB16694SS 30w LED 1500mm Jubilee XL luminaire. SmartScan.
	1	WJB16694SS 30w LED 1500mm Jubilee XL luminaire. SmartScan. SmartScan emergency Version.
	1	KB16108SS 37w LED Kanby LED Controller luminaire. SmartScan.
	1	WKB16108SS 37w LED Kanby LED Controller luminaire. SmartScan. SmartScan Emergency Version.
	1	CT16174SS 16w LED Cobalt SmartScan luminaire.
	1	WCT16174SS 16w LED Cobalt SmartScan luminaire. SmartScan Emergency version.
	0	CT15814SS 16W Cobalt. SmartScan. Satin
	1	WCT15814SS 16W Cobalt. SmartScan. Satin. SmartScan Emergency
	0	GLO16484LF 20w LED Glodome circular luminaire. Non-dimming
	1	DOT16499LF 17w LED circular DOT luminaire. Opal Version.
	0	RL19111SS 34w LED 4000K Realta high performance SmartScan exterior luminaire. Polycarbonate Cover. Area Distribution
	2	WRL19111SS 34w LED 4000K Realta high performance SmartScan exterior SmartScan emergency luminaire. Polycarbonate Cover. Area Distribution
	0	RL19069SS 8w LED Realta SmartScan polycarbonate refractor LED high performance exterior luminaire. Wide Distribution. 4000K.
	4	WRL19069SS 8w LED Realta SmartScan polycarbonate refractor LED high performance exterior luminaire. Wide Distribution. SmartScan Emergency Version. 4000K.
	1	TP19773SS 30w LED 1500mm Thoroproof SmartScan anti-corrosive luminaire. IP54.
	0	WTP19773SS 30w LED 1500mm Thoroproof SmartScan anti-corrosive luminaire. IP54. SmartScan Emergency
	1	SS20213 SmartScan Touch wall plate - mains

- Notes
1. This drawing is for schematic purposes and installation shall fully comply with BS7671 (or National equivalent).
 2. Luminaire positions are indicative only and subject to confirmation of ceiling types. Ceiling voids and other obstructions not taken into consideration unless shown on the layout.
 3. Lighting designs will be carried out in accordance with information provided. Where no information is provided, lighting design criteria will be selected in accordance with the minimum required values as detailed within guidance provided by CIBSE/SLL or British/Irish Standards. Thorlux will not be held responsible if inaccurate, incomplete or out of date information is provided.
 4. It is the installing contractors responsibility to ensure all luminaires and lighting controls are suitable for the environment and ceiling type for which they are proposed.
 5. In designing this initial scheme we have prejudged areas which are likely to require emergency lighting in compliance with BS5266-1, -7 & -8 but it is the customer's responsibility to risk assess all areas, ensure coverage of all "positions of emphasis" and notify changes. Consequently, our design is limited pending this information.
 6. When required, interconnecting leads and mains starter leads have been included. Horizontal distance between luminaires has been used to determine the length of interconnecting leads. Additional leads to be ordered separately if required, for example, to allow for unforeseen obstructions within the ceiling void.
 7. PIR positions are indicative only and are subject to quantity and location changes dependant upon room and furniture layouts.
 8. The provided Lighting Design has been completed by others and Thorlux Lighting accept no design responsibility relating to this scheme.

The proposed lighting scheme is subject to our terms and conditions which can be found here: <http://www.thorlux.com/terms>



Merse Road, North Moons Moat,
Redditch, Worcestershire
B98 9HH.
Telephone 01527 583200
Facsimile 01527 584177
E-Mail lighting.design@thorlux.co.uk
Web site: www.thorlux.com

PROPOSED LIGHTING LAYOUT

Ty Brynseion


Ground Floor

SCALE	1:100 @ A1
DATE	06/09/2022
DRN. BY	EP
DESIGNER	GM

DRAWING No.

558330-01

BASED ON CUSTOMER DRG.	REV.
ORIGINATOR:	DATE

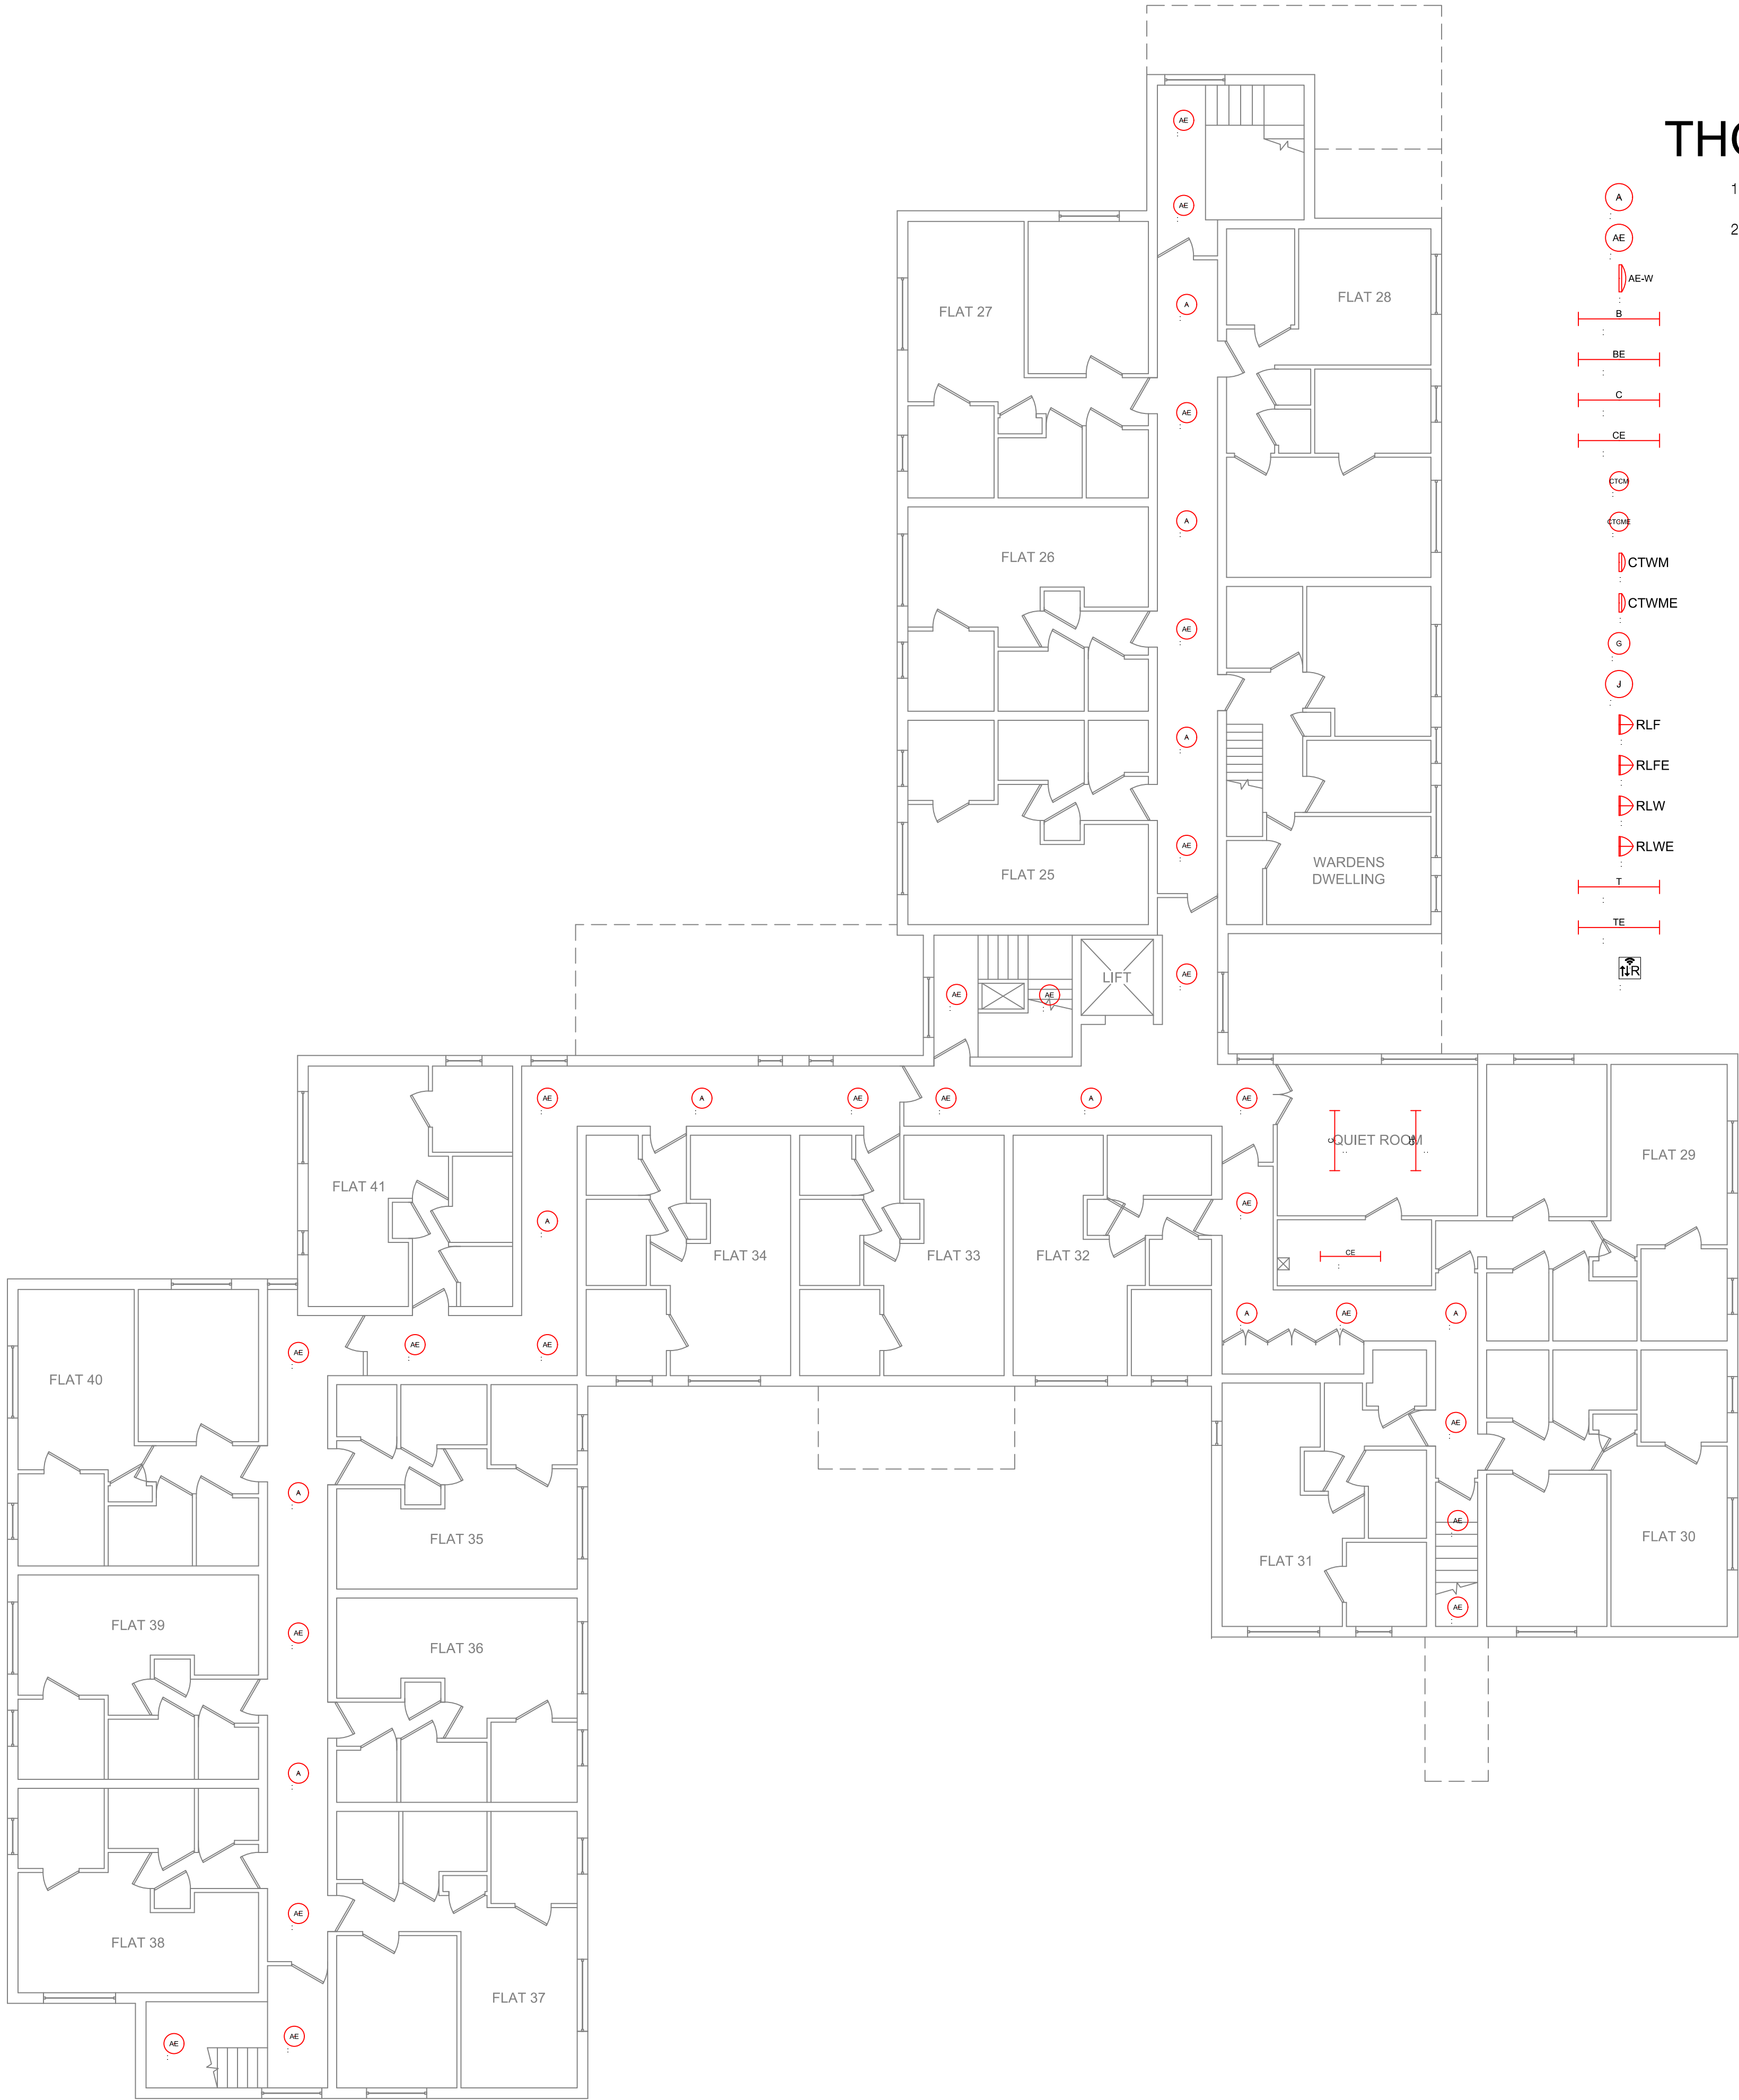

THORLUX KEY

	10	DOT16490SS 17w LED circular DOT SmartScan luminaire. Satin sparkle Version.
	24	WDT16490SS 17w LED circular DOT SmartScan luminaire. SmartScan Emergency. Satin Sparkle Version.
	0	WDT16490SS 17w LED circular DOT SmartScan luminaire. SmartScan Emergency. Satin Sparkle Version. Wall mounted
	0	JUB16694SS 30w LED 1500mm Jubilee XL luminaire. SmartScan.
	0	WJB16694SS 30w LED 1500mm Jubilee XL luminaire. SmartScan. SmartScan emergency Version.
	1	KB16108SS 37w LED Kanby LED Controller luminaire. SmartScan.
	2	WKB16108SS 37w LED Kanby LED Controller luminaire. SmartScan. SmartScan Emergency Version.
	0	CT16174SS 16w LED Cobalt SmartScan luminaire.
	0	WCT16174SS 16w LED Cobalt SmartScan luminaire. SmartScan Emergency version.
	0	CT15814SS 16W Cobalt. SmartScan. Satin
	0	WCT15814SS 16W Cobalt. SmartScan. Satin. SmartScan Emergency
	0	GL016484LF 20w LED Glodome circular luminaire. Non-dimming
	0	DOT16499LF 17w LED circular DOT luminaire. Opal Version.
	0	RL19111SS 34w LED 4000K Realta high performance SmartScan exterior luminaire. Polycarbonate Cover. Area Distribution
	0	WRL19111SS 34w LED 4000K Realta high performance SmartScan exterior SmartScan emergency luminaire. Polycarbonate Cover. Area Distribution
	0	RL19069SS 8w LED Realta SmartScan polycarbonate refractor LED high performance exterior luminaire. Wide Distribution. 4000K.
	0	WRL19069SS 8w LED Realta SmartScan polycarbonate refractor LED high performance exterior luminaire. Wide Distribution. SmartScan Emergency Version. 4000K.
	0	TP19773SS 30w LED 1500mm Thoroproof SmartScan anti-corrosive luminaire. IP54.
	0	WTP19773SS 30w LED 1500mm Thoroproof SmartScan anti-corrosive luminaire. IP54. SmartScan Emergency
	0	SS20213 SmartScan Touch wall plate - mains

- | REV. | DATE | BY | DESCRIPTION |
|------|------|----|-------------|
| | | | |
- Notes
- This drawing is for schematic purposes and installation shall fully comply with BS7671 (or National equivalent).
 - Luminaire positions are indicative only and subject to confirmation of ceiling types. Ceiling voids and other obstructions not taken into consideration unless shown on the layout.
 - Lighting designs will be carried out in accordance with information provided. Where no information is provided, lighting design criteria will be selected in accordance with the minimum required values as detailed within guidance provided by CIBSE/SLL or British/Irish Standards. Thorlux will not be held responsible if inaccurate, incomplete or out of date information is provided.
 - It is the installing contractors responsibility to ensure all luminaires and lighting controls are suitable for the environment and ceiling type for which they are proposed.
 - In designing this initial scheme we have prejudged areas which are likely to require emergency lighting in compliance with BS5266-1, -7 & -8 but it is the customer's responsibility to risk assess all areas, ensure coverage of all "positions of emphasis" and notify changes. Consequently, our design is limited pending this information.
 - When required, interconnecting leads and mains starter leads have been included. Horizontal distance between luminaires has been used to determine the length of interconnecting leads. Additional leads to be ordered separately if required, for example, to allow for unforeseen obstructions within the ceiling void.
 - PIR positions are indicative only and are subject to quantity and location changes dependant upon room and furniture layouts.
 - The provided Lighting Design has been completed by others and Thorlux Lighting accept no design responsibility relating to this scheme.

The proposed lighting scheme is subject to our terms and conditions which can be found here: <http://www.thorlux.com/terms>



Merse Road, North Moons Moat,
Redditch, Worcestershire
B98 9HH.
Telephone 01527 583200
Facsimile 01527 584177
E-Mail lighting.design@thorlux.co.uk
Web site: www.thorlux.com

PROPOSED LIGHTING LAYOUT

Ty Brynseion
First Floor

SCALE	1:100 @ A1
DATE	06/09/2022
DRN. BY	EP
DESIGNER	GM

DRAWING No.	
558330-02	
BASED ON CUSTOMER DRG.	REV.
ORIGINATOR:	DATE