


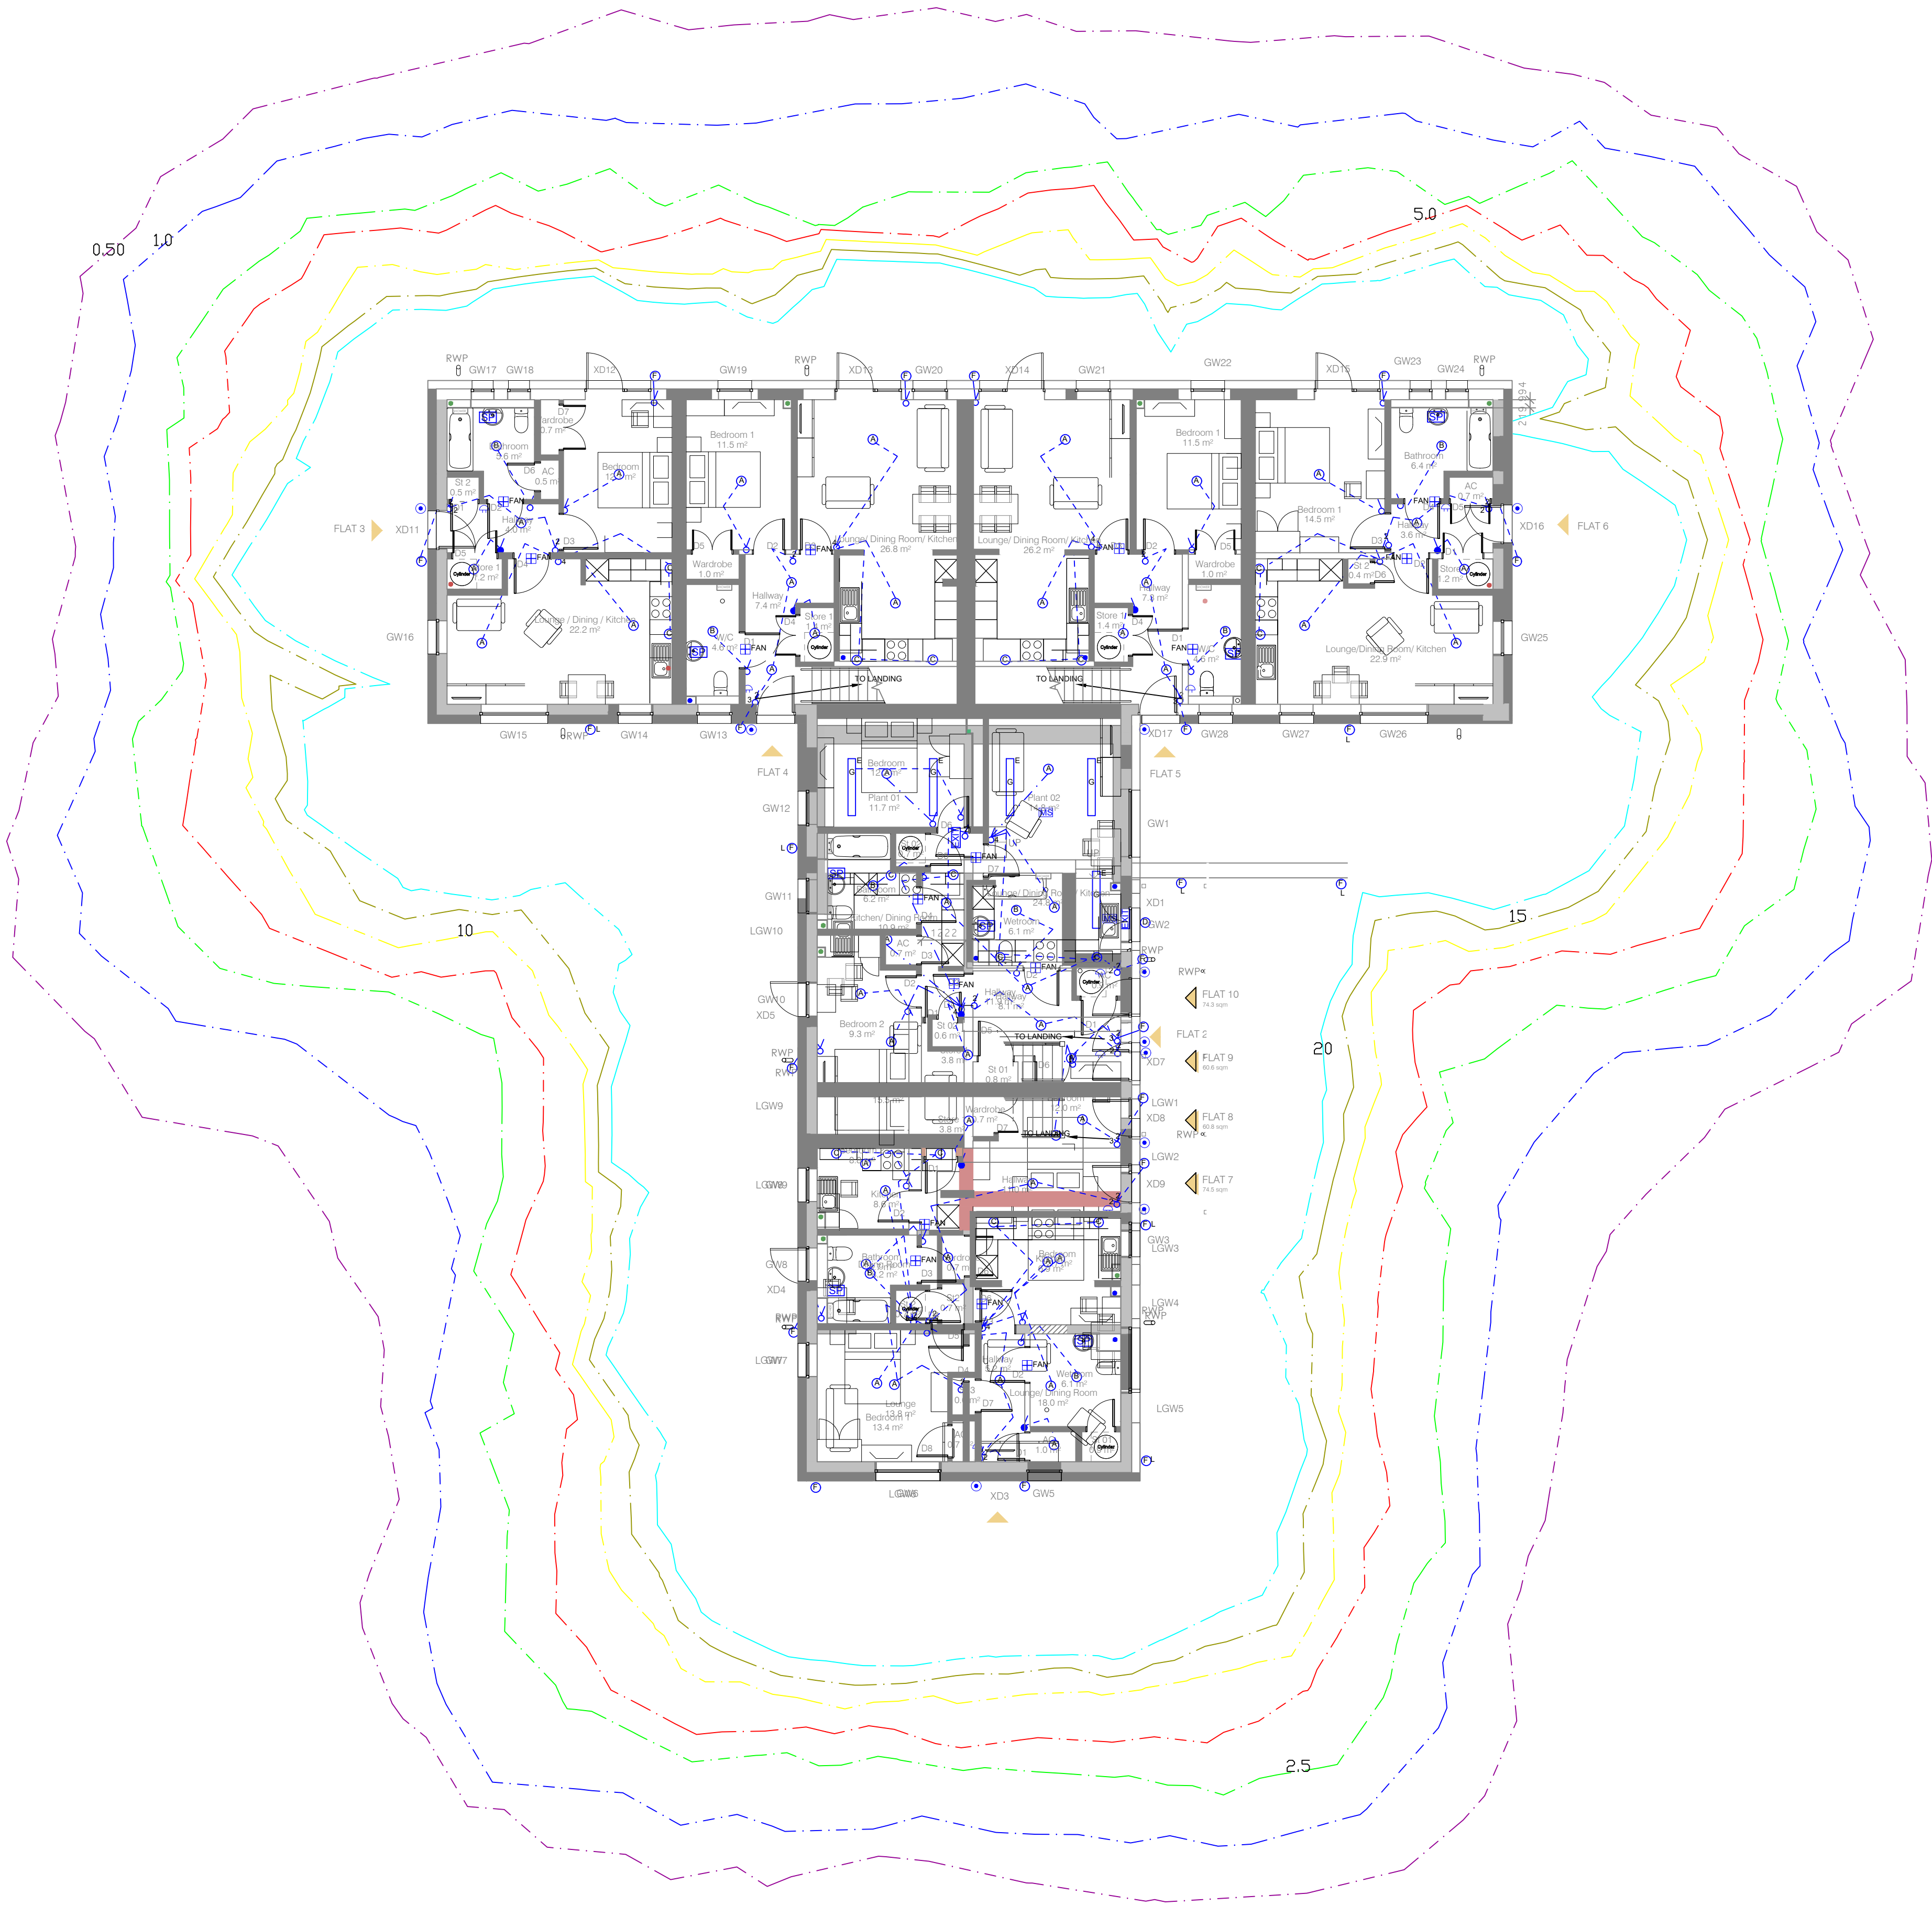

LUMINAIRE SCHEDULE


- A LOW ENERGY LED PENDANT [BATTENHOLDER IN KITCHEN AND STORES OVER 1m2]
- B 28w IP65 LED SURFACE BULKHEAD
- C 1x5w 300mm LED UNDER UNIT WALL LIGHT
- D 6.5w LED EMER IP65 BULKHEAD
- F 35w EYELID TYPE LED SURFACE IP65 BULKHEAD C/W PC AND PIR
- G 29w IP65 1500mm LED SURFACE

WHERE E DENOTES EMERGENCY VERSION

ALL ABOVE TO BE TAMLITE [KRIS JONES 07961 458510]

EXIT- SURFACE MAINTAINED "EXIT SIGN" C/W DIRECTIONAL ARROW & LEGEND

DISCLAIMER:
This drawing is intended for guidance
purposes. All dimensions, Scale and
Positional detail are approximate only.
Measurements should be taken on site.

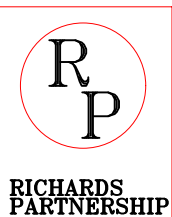

21/03/24		SK	
DATE	REV	STATUS	DETAILS
CHARTERED ENGINEERS AND SURVEYORS			DATE:
TEL 07792859191			21-03-24
Project- LLYSFAEN - MERTHYR HA			DRAWN:
			NR
DRG TITLE: EXTERNAL LUX LEVELS			DRG No:
14 THISTLEBOON RD, MUMBLES, SWANSEA. SA3 4HE			356/2/SK01
			SCALE:
			1:100 @ A1