




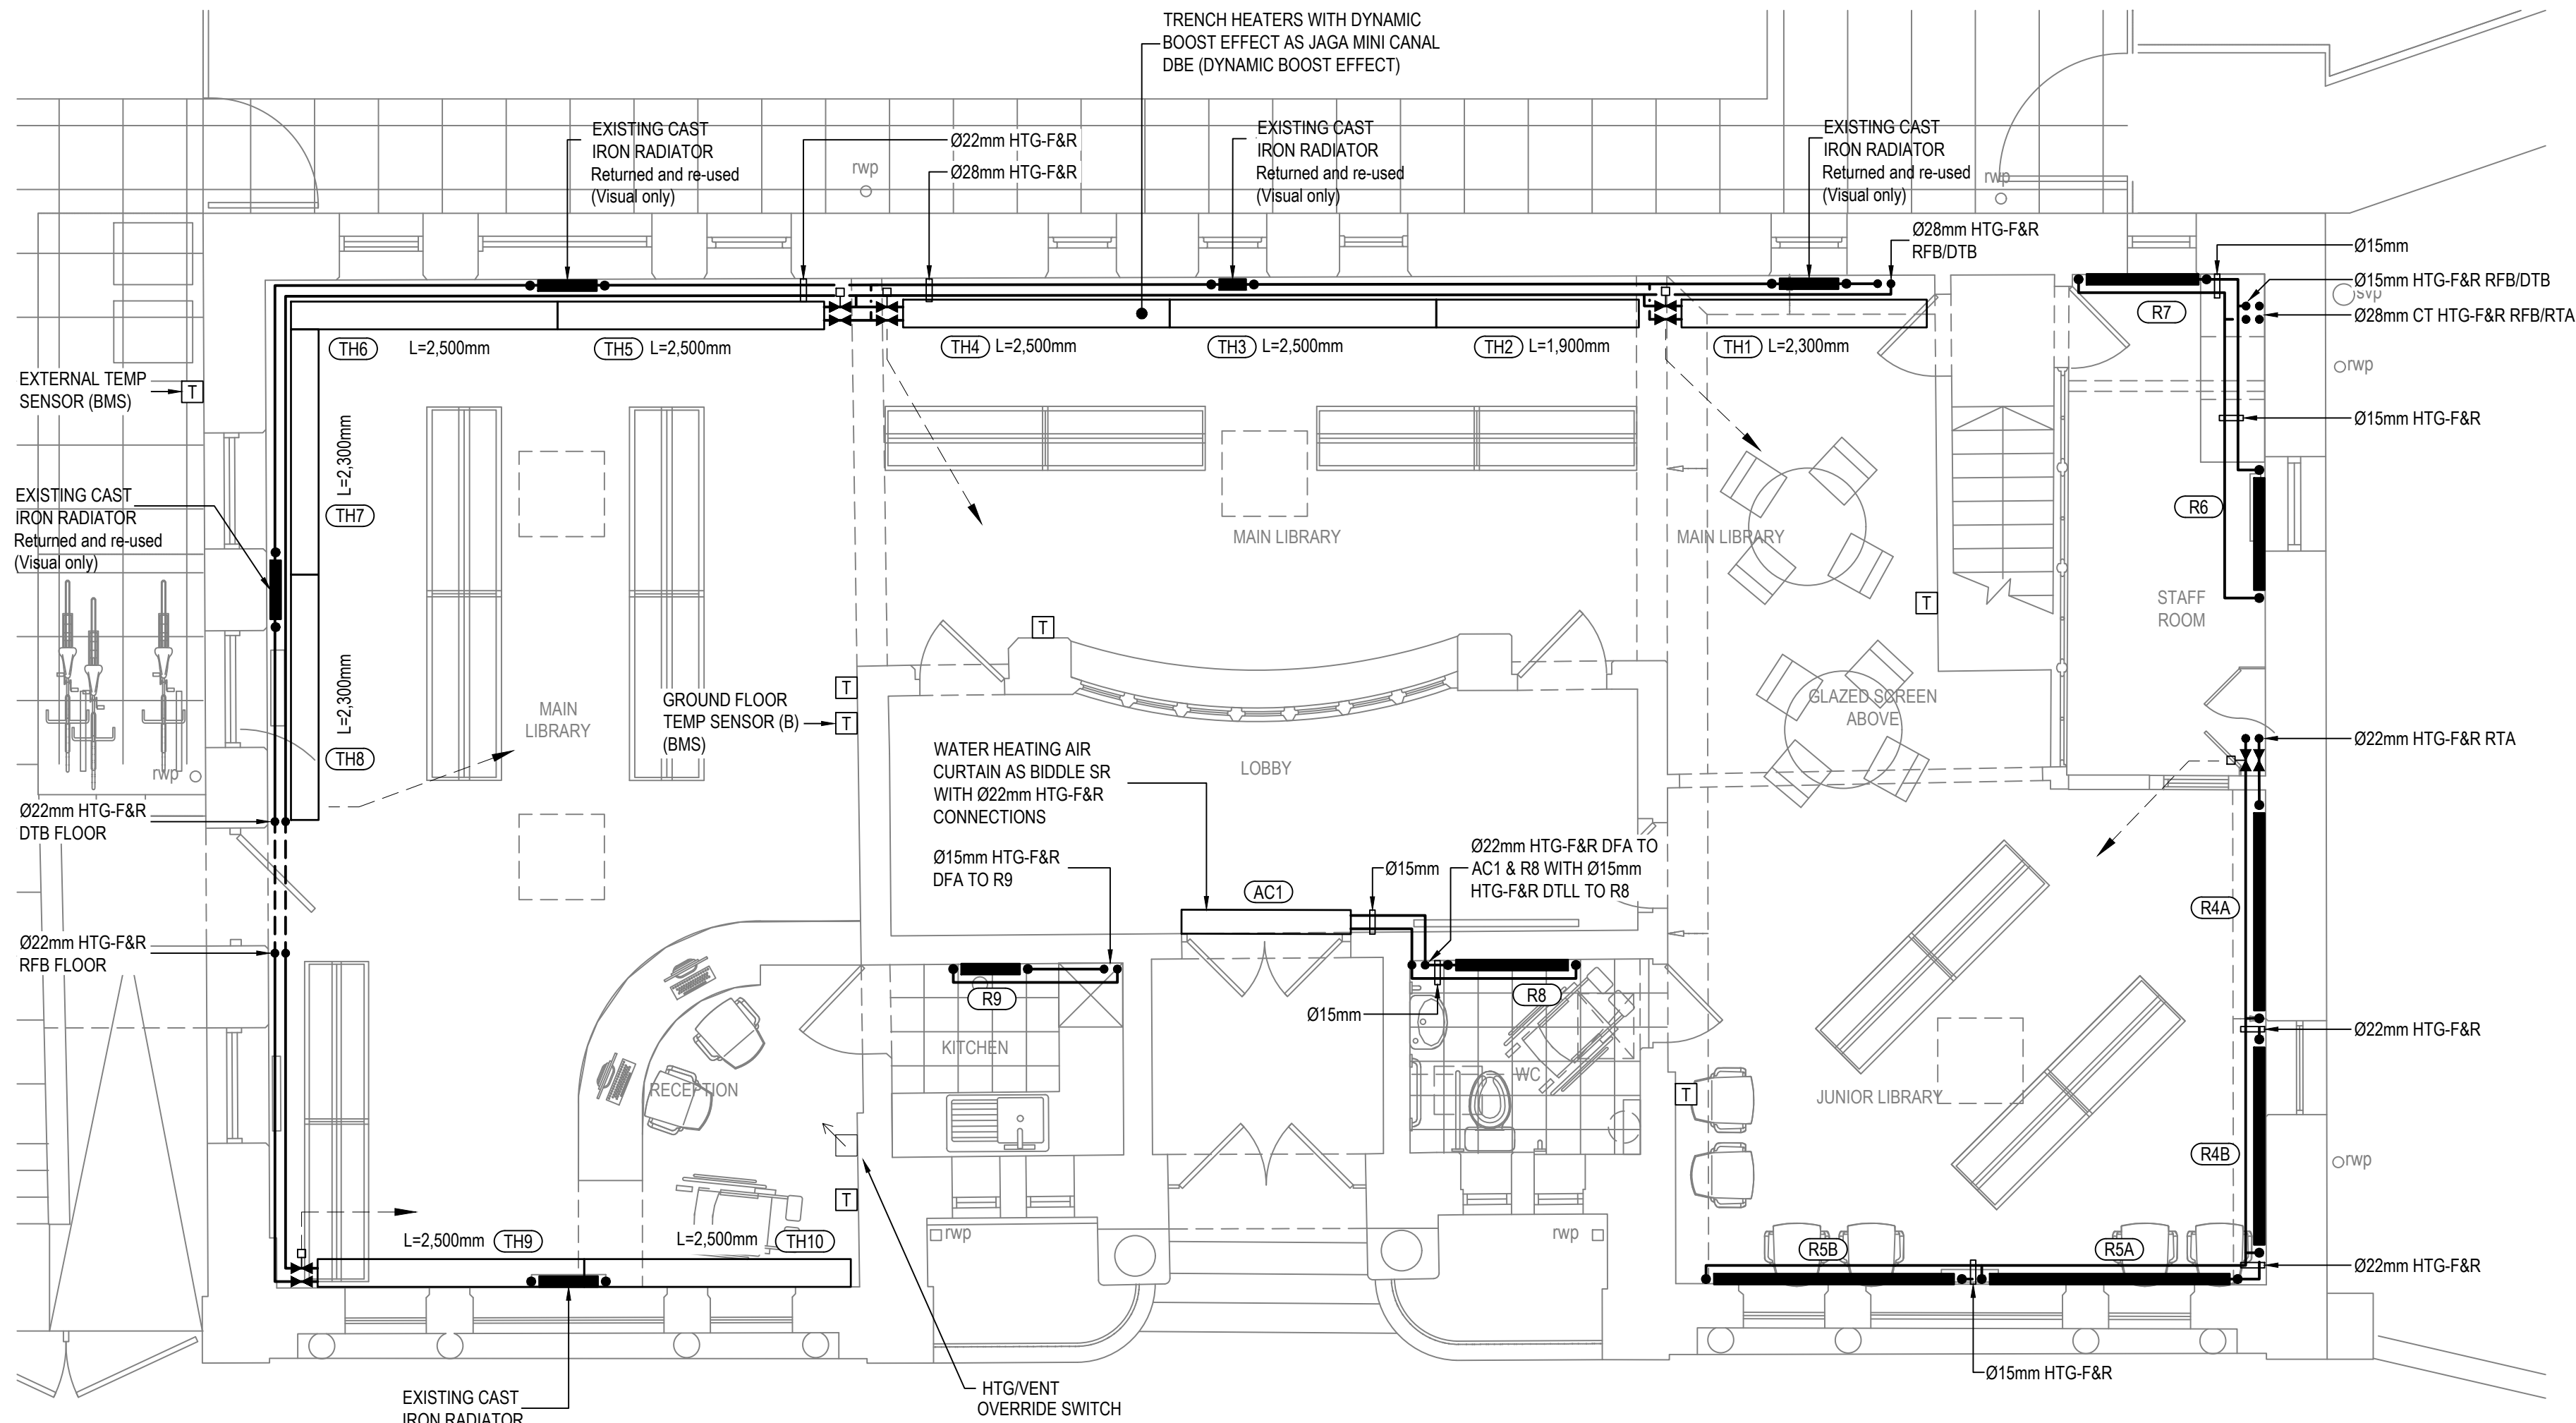


GROUND FLOOR
SCALE 1:50

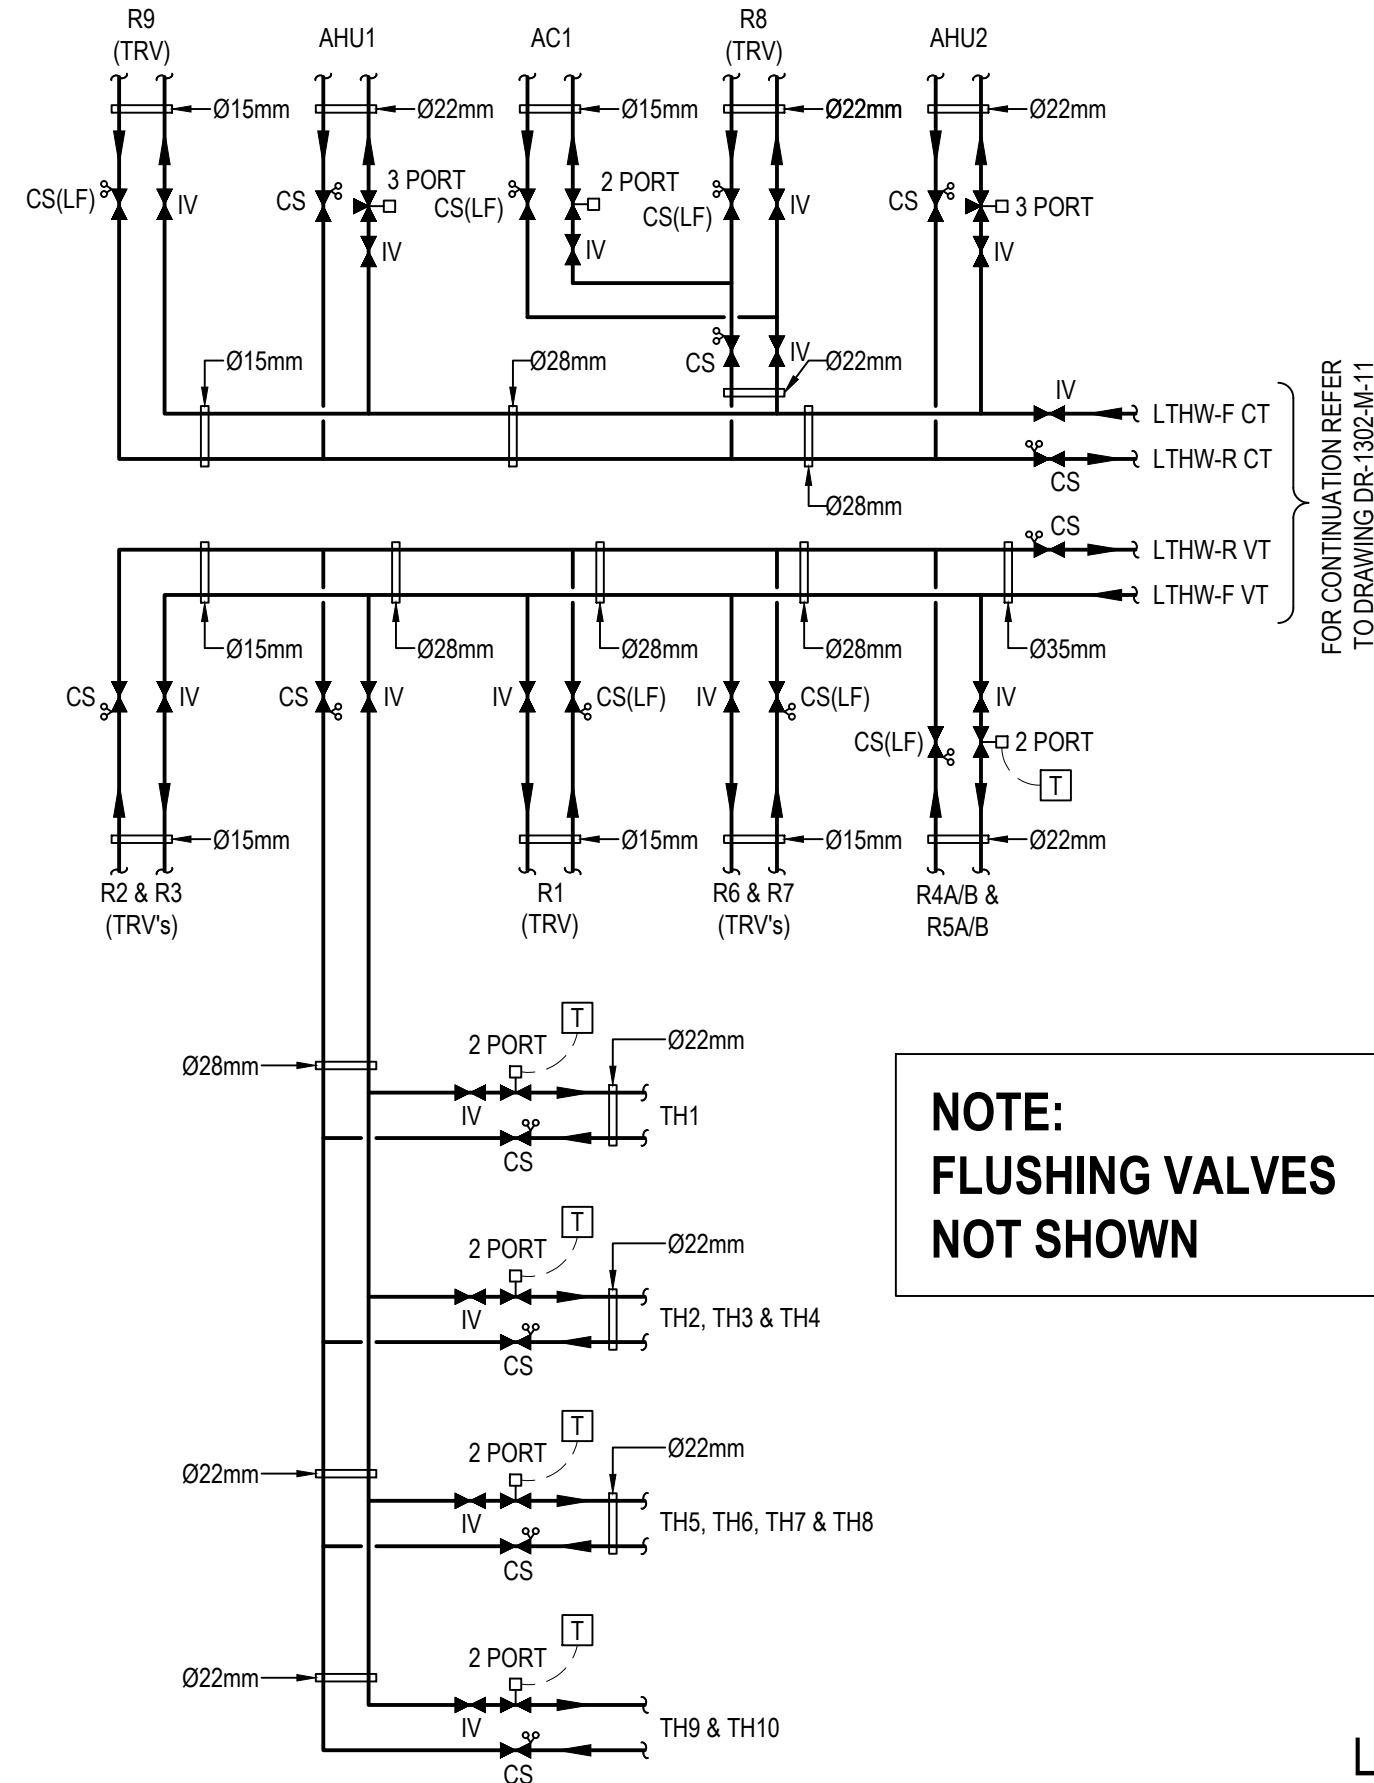

**NOTE:
FLUSHING VALVES
NOT SHOWN**

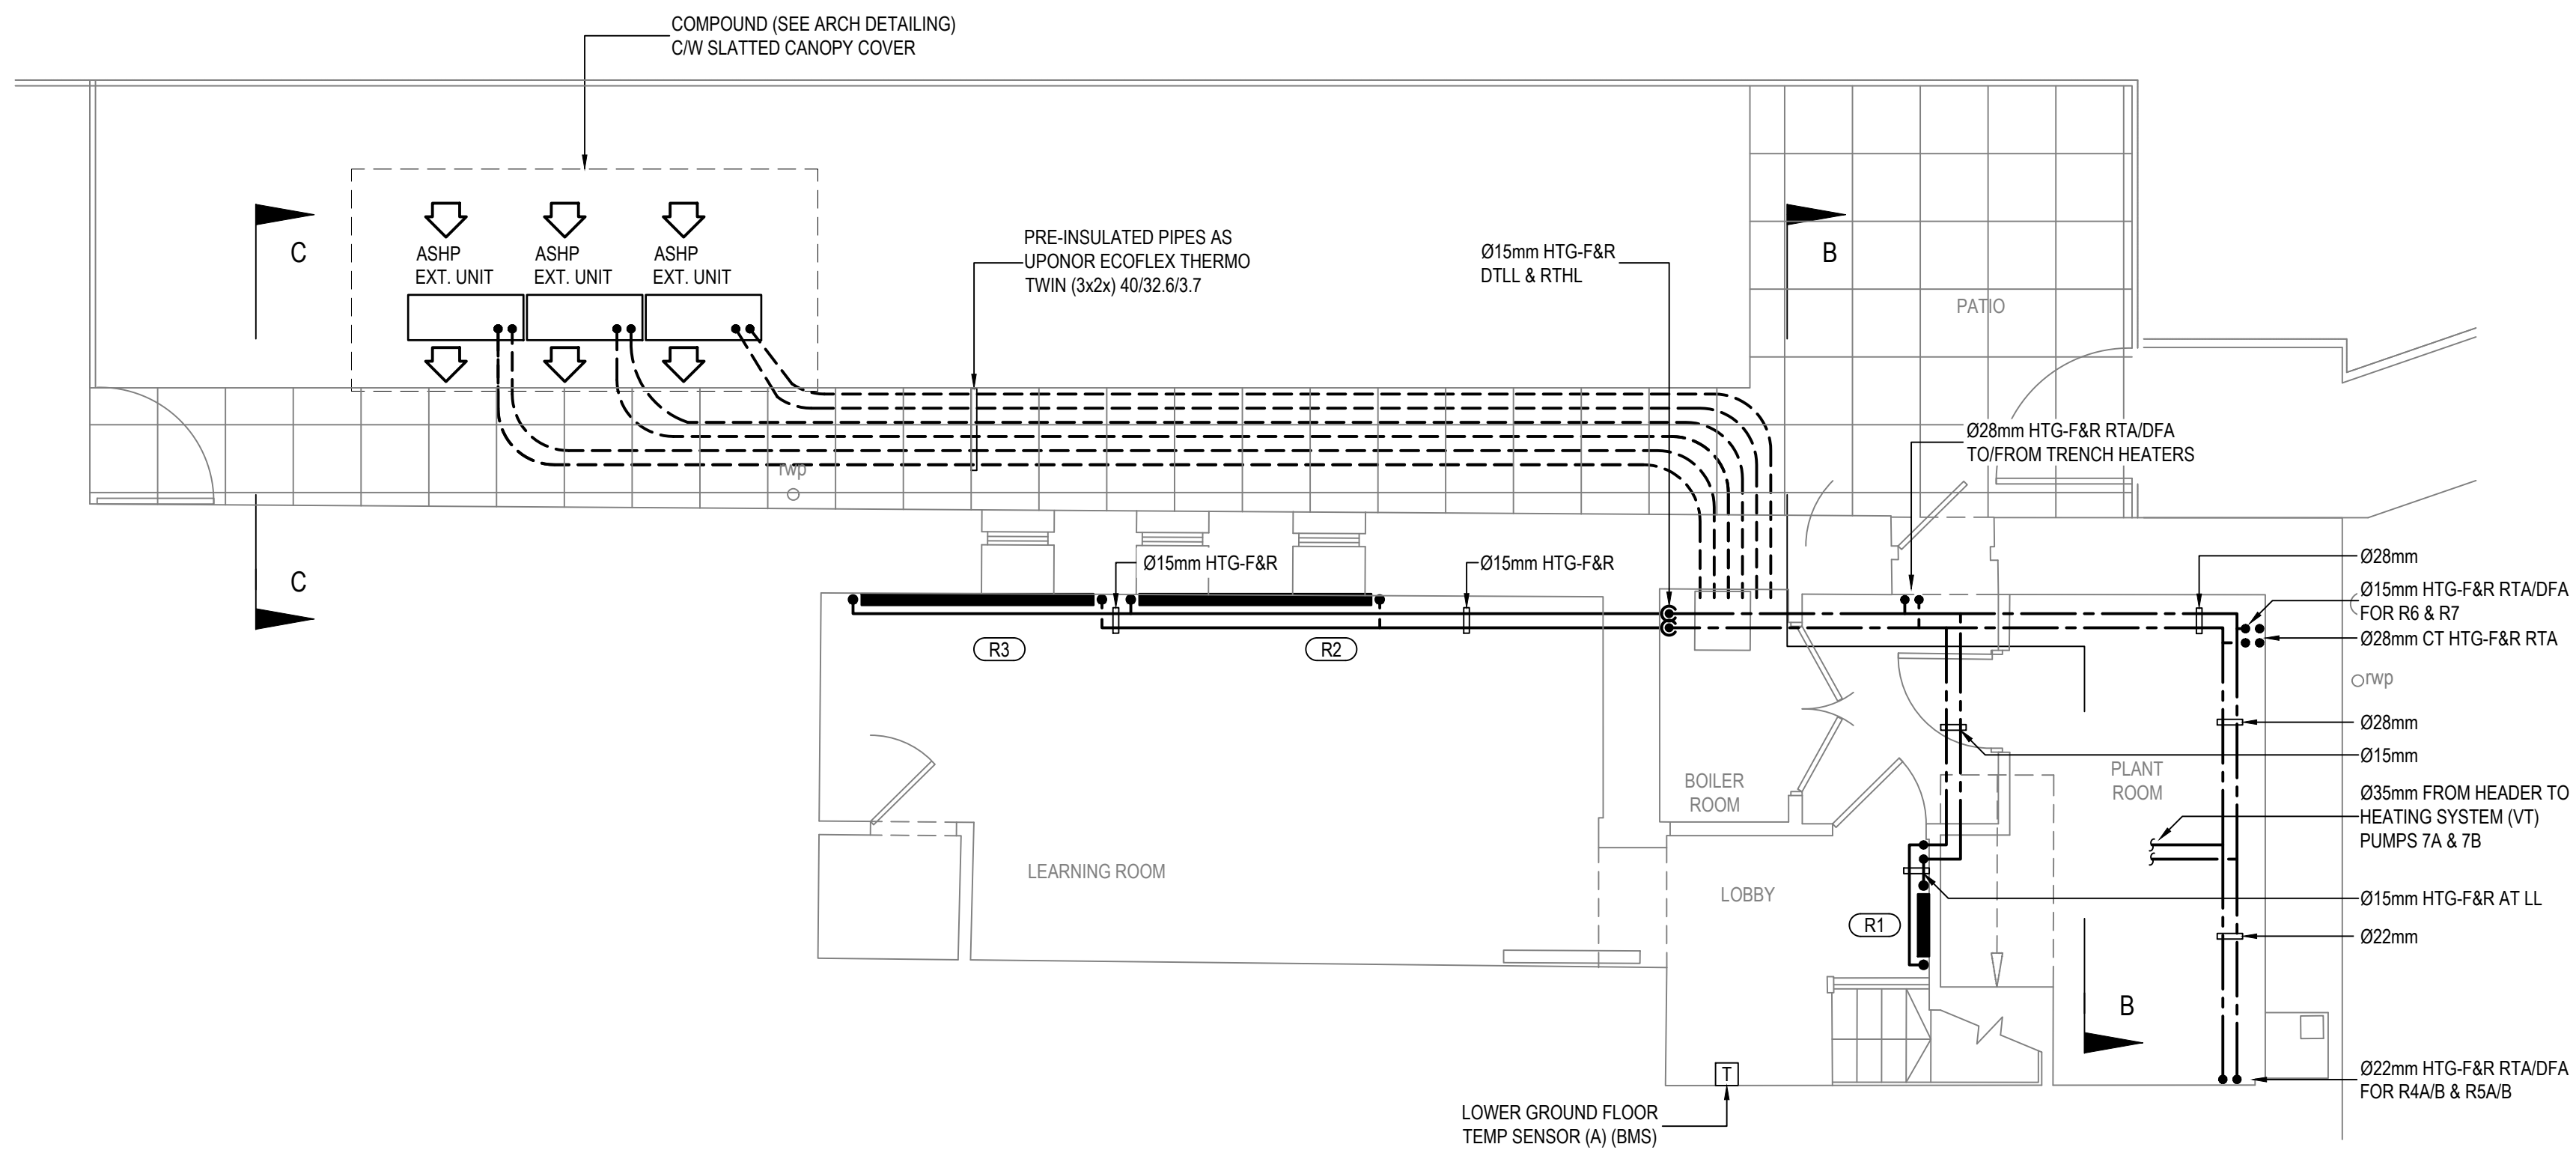

 LOWER GROUND FLOOR
SCALE 1:50



TENDER ISSUE							
T1	TENDER ISSUE				KS	RW	02.05.23
T0	TENDER ISSUE				KS	RW	28.04.23
REV	DESCRIPTION				CHK	APP	DATE
Client:							
MERTHYR TYDFIL COUNTY BOROUGH COUNCIL CIVIC CENTRE, CASTLE STREET, MERTHYR TYDFIL, CF47 8AN						 MERTHYR TYDFIL County Borough Council Cynghor Bwrdeistref Sirol MERTHYR TYDFIL	
4 Ty Nant Court, Morganstown, Cardiff, CF15 8LW 4: 02920 811266 F: 02920 814459 W: www.dracconsulting.com						 DRAC Building Services and Sustainability Consultants	
Project:							
TRENHARRIS LIBRARY							
Drawing Title:							
PROPOSED LOWER GROUND FLOOR & GROUND FLOOR HEATING LAYOUT							
Scale @ A1 1:50		Drawn M.P.	Checked K.S.	Approved R.W.	Date 28.04.23		
Drawing No.					Revision T1		
DR-1302-M-06							