


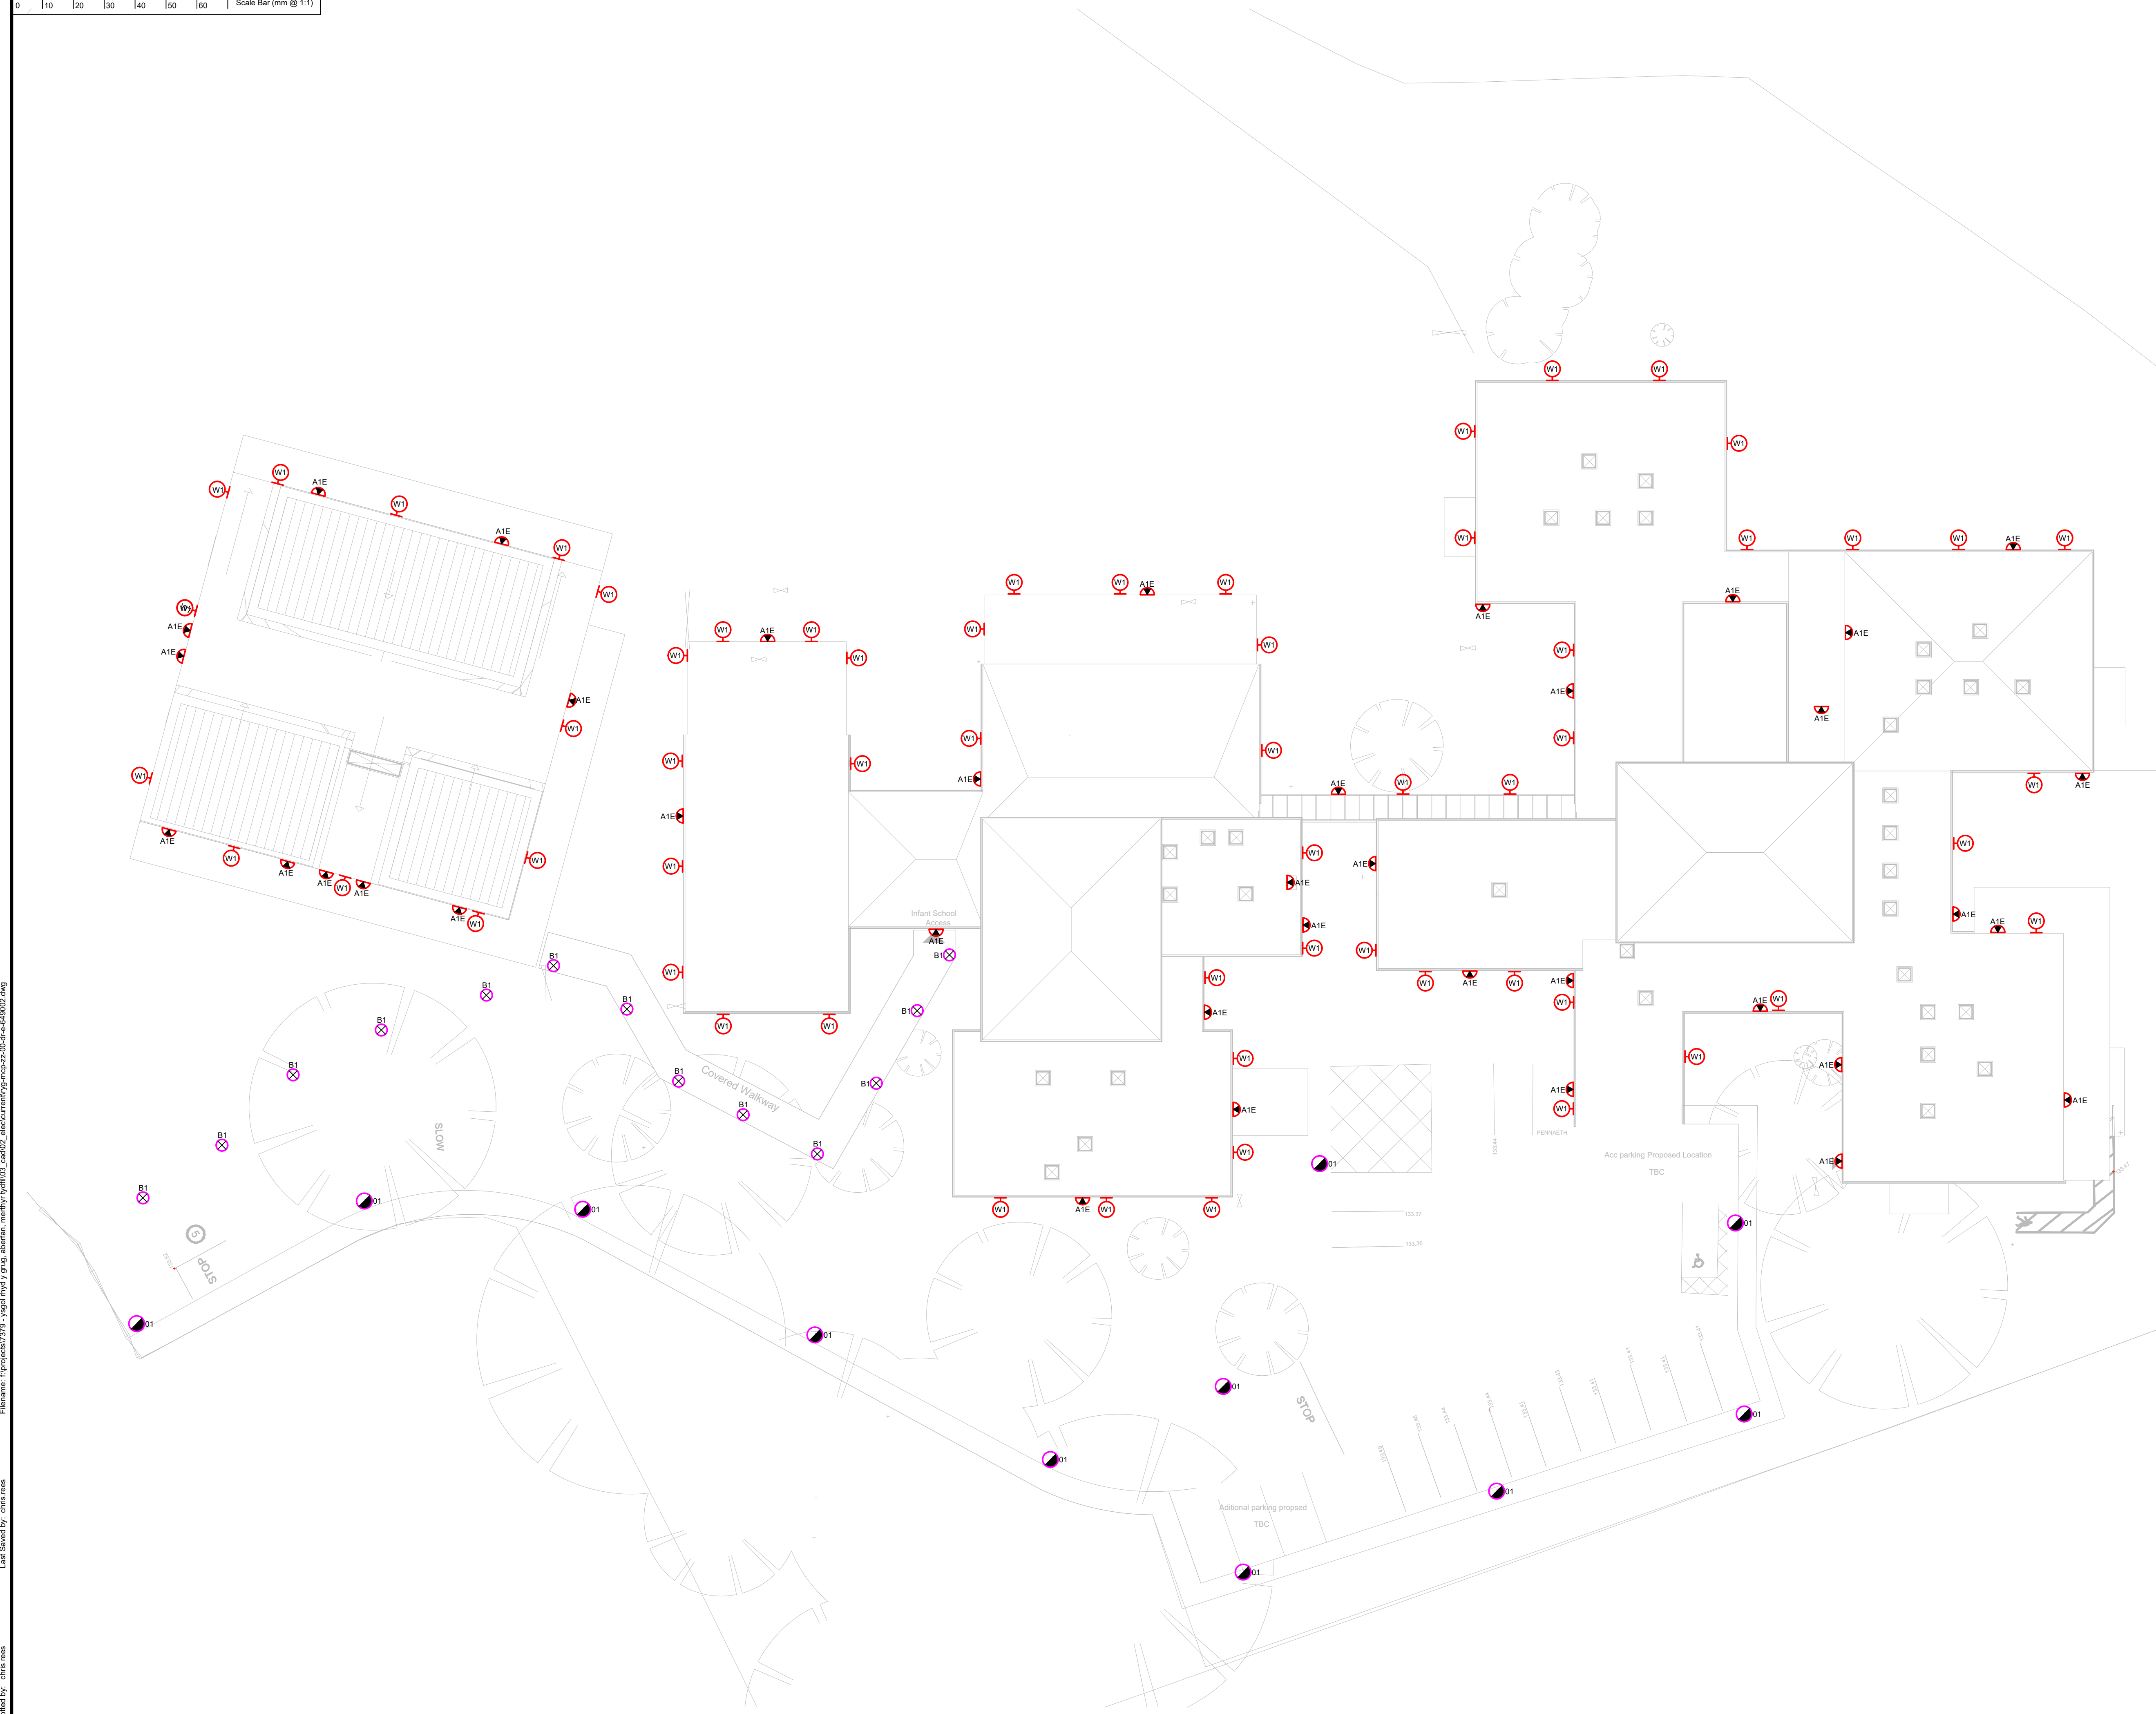

- This is not an installation drawing.
- The final coordination of services, specialist Sub-Contractors, and building structure is the responsibility of the building services Contractor.
- Do not scale from this drawing.
- This drawing shall be read in conjunction with the MEP Specification.
- The installation of services shall be in compliance with the workmanship clauses detailed in the Specification.

Notes

Legend

- | | | |
|---|-----|-------------------|
|  | A1E | AME2 NM3 LE3 |
|  | B1 | Opus L30 BL C83 |
|  | W1 | OPWUP L15 AS C727 |
|  | 01 | OPUCL L70 W |

Safety, Health & Environmental Information

In addition to the hazards / risks normally associated with the types of work detailed on this drawing, note the following:

Construction

1. Refer to designers risk register, construction risk register
And asbestos register

Maintenance / Cleaning

1. Refer to designers risk register, construction risk register
And asbestos register

Decommissioning / Demolition

1. Refer to designers risk register, construction risk register
And asbestos register

It is assumed that all works will be carried out by a competent contractor working, where appropriate, to an approved method statement

Details	Eng	Date	Rev

Revisions

Consulting Engineers
Faraday House, Terra Nova Way
Penarth Marina, Cardiff CF64 1SA
Tel. (029) 2035 2450
Fax. (029) 2035 2451
www.mccannp.com
office@mccannp.com



Job Title
Ysgol Rhyd Y Grug
Aberfan
Merthyr Tydfil

Drawing Title

Electrical Engineering Services

Proposed Site External Lighting Layout

Scale  A1	Date	Authorised	Checked	Engineer	Drawn
1:200	Mar 26	CM	CM	NY	CR
McConn Ref	Status			Status Code	Revision
7379	Preliminary Issue			S5	P01
Project	Origin	Volume	Level	Type	Discipline Number
RYG	MCP	ZZ	00	DR	E 649002