
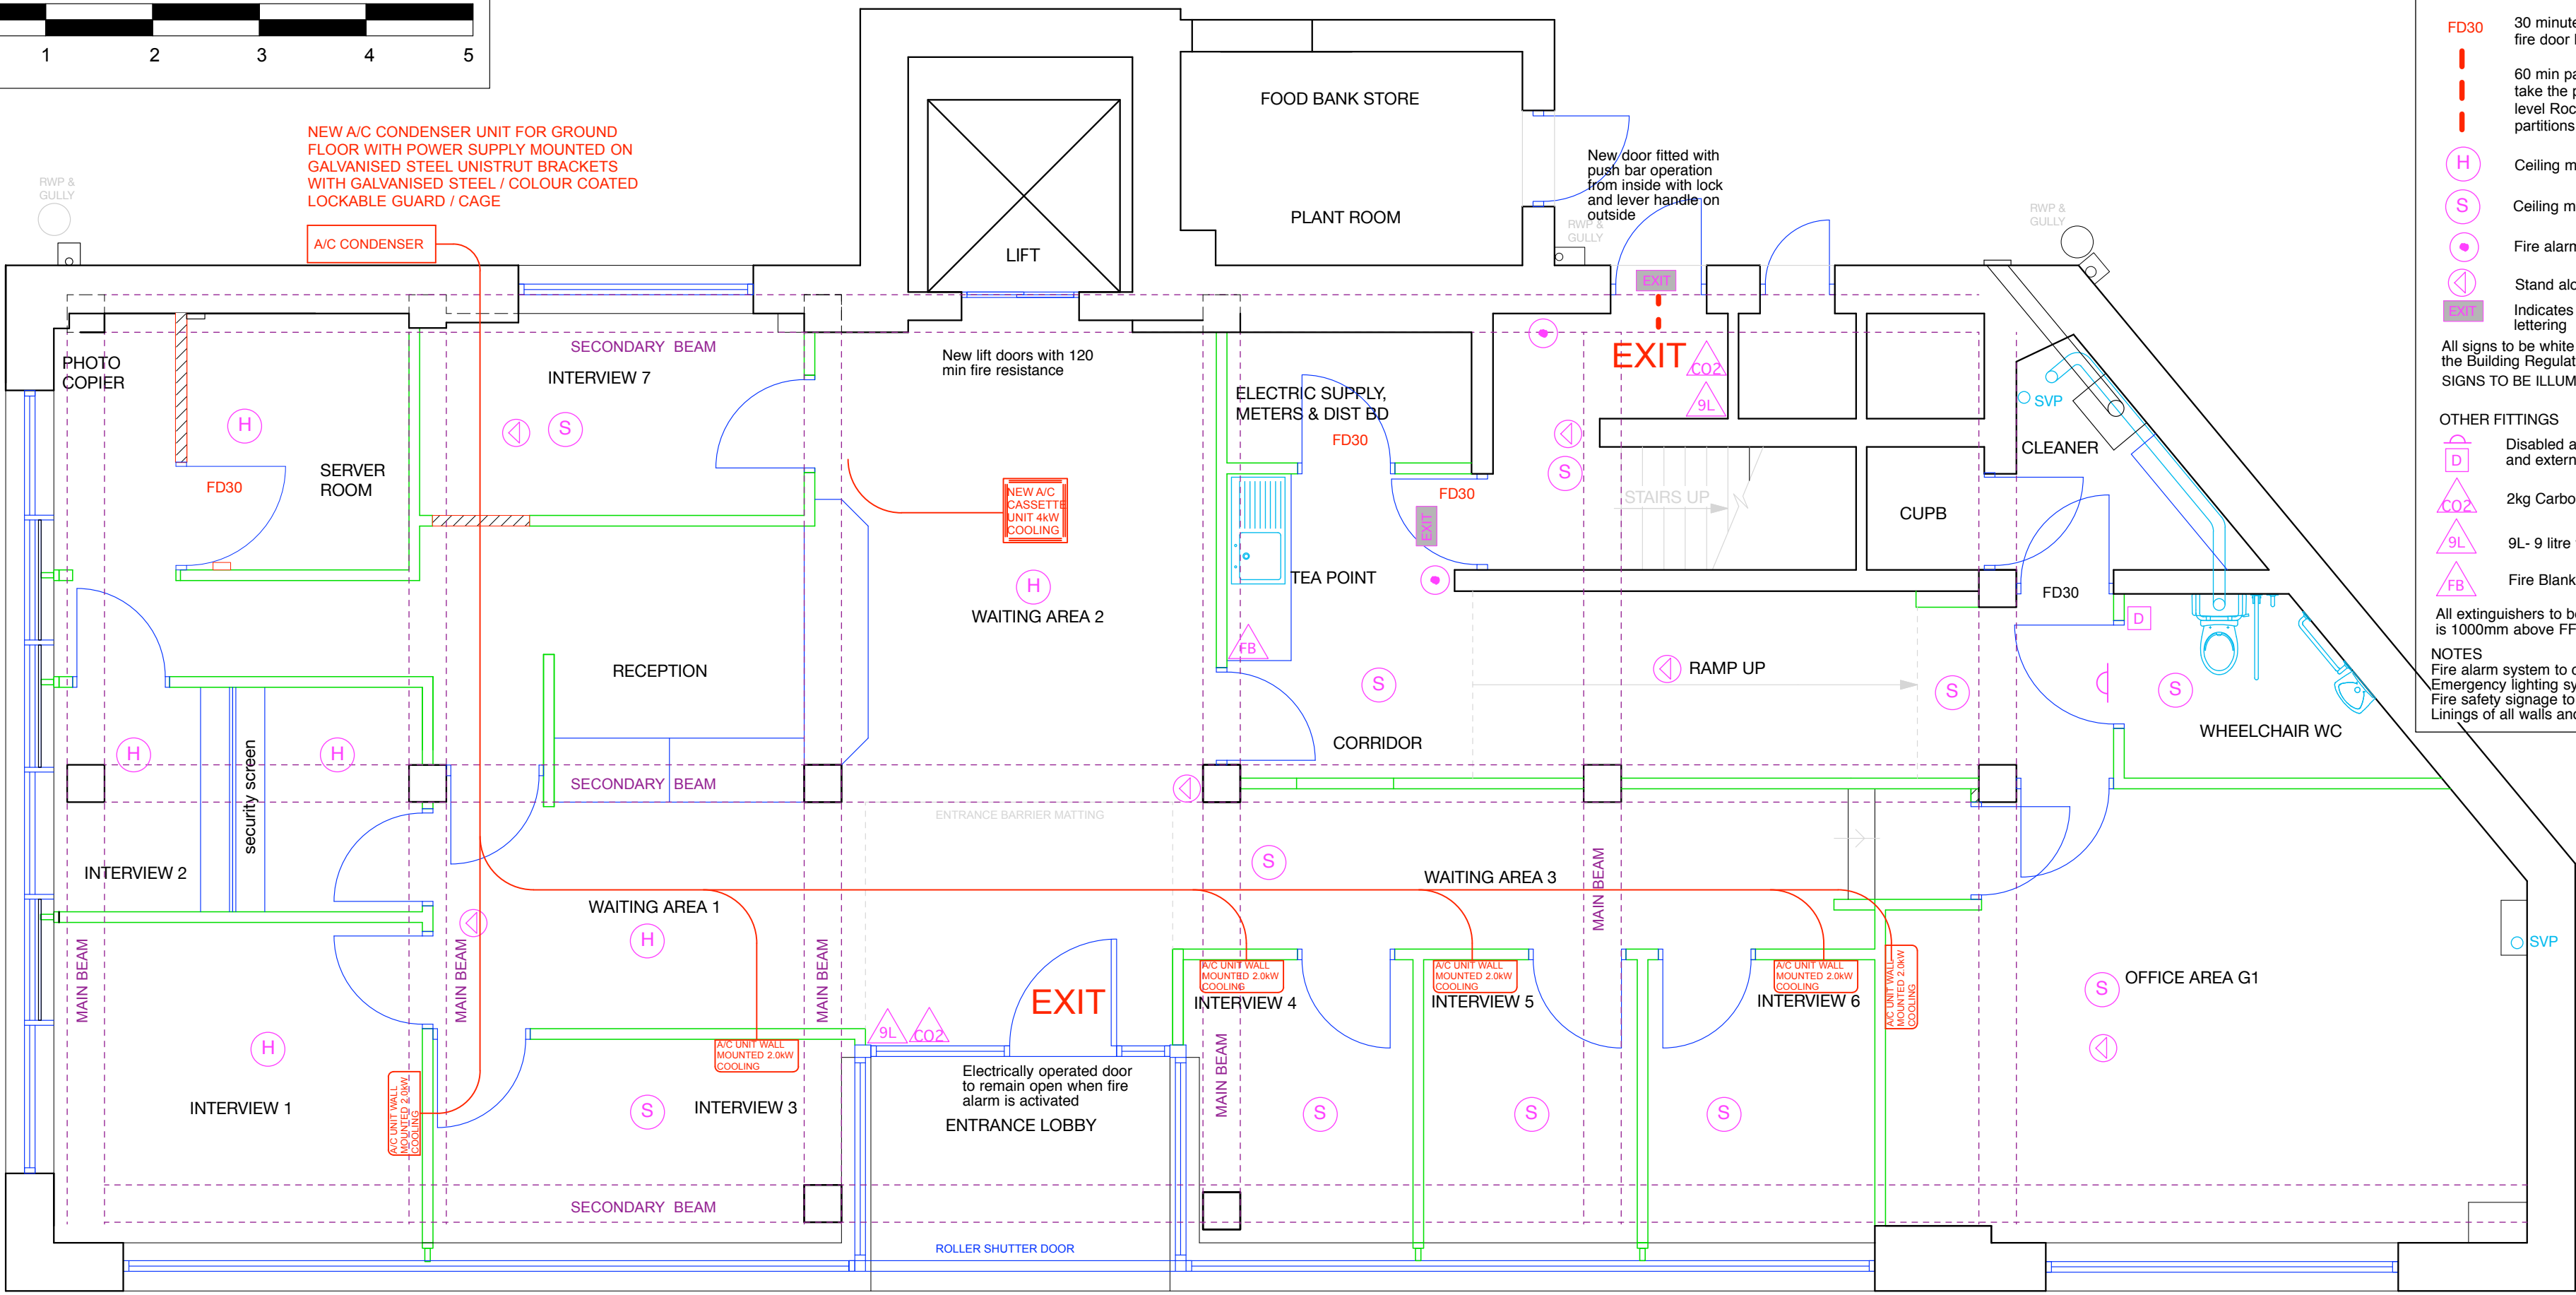


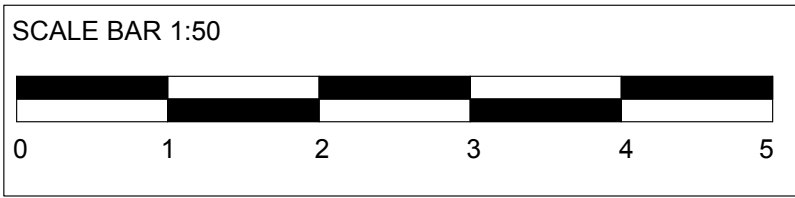

FIRE STRATEGY

FIRE DETECTION & ALERT & FIGHTING EQUIPMENT LEGEND

- FD30** 30 minute fire door with door closer, smoke/intumescent seal and fire door keep shut signage
- 60 min partition taken up to structural ceiling, where it is not possible to take the partition above the ceiling level Rockwool quilt fire barriers are to be installed. All glazing within these partitions is to be 30 min fire rated.
- H** Ceiling mounted heat detector
- S** Ceiling mounted smoke detector
- Fire alarm break glass call point
- ⬇** Stand alone loop sounder
- Indicates illuminated FIRE EXIT RUNNING MAN notices in 100mm block lettering

All signs to be white lettering on green background to conform to Document B of the Building Regulations 2007.
SIGNS TO BE ILLUMINATED BY THE GENERAL AND SECONDARY LIGHTING SYSTEM


OTHER FITTINGS

- D** Disabled alarm fitting with pull cord switch and external alarm indicator/sounder
- CO2** 2kg Carbon Dioxide Extinguisher
- 9L** 9L- 9 litre water extinguisher 2No
- FB** Fire Blanket


NOTES

- Fire alarm system to comply with BS5839
- Emergency lighting system to comply with BS5266
- Fire safety signage to comply with BS5499
- Linings of all walls and ceilings to be National class 0 and European class B-s3, d2

GROUND FLOOR - NEW A/C UNITS

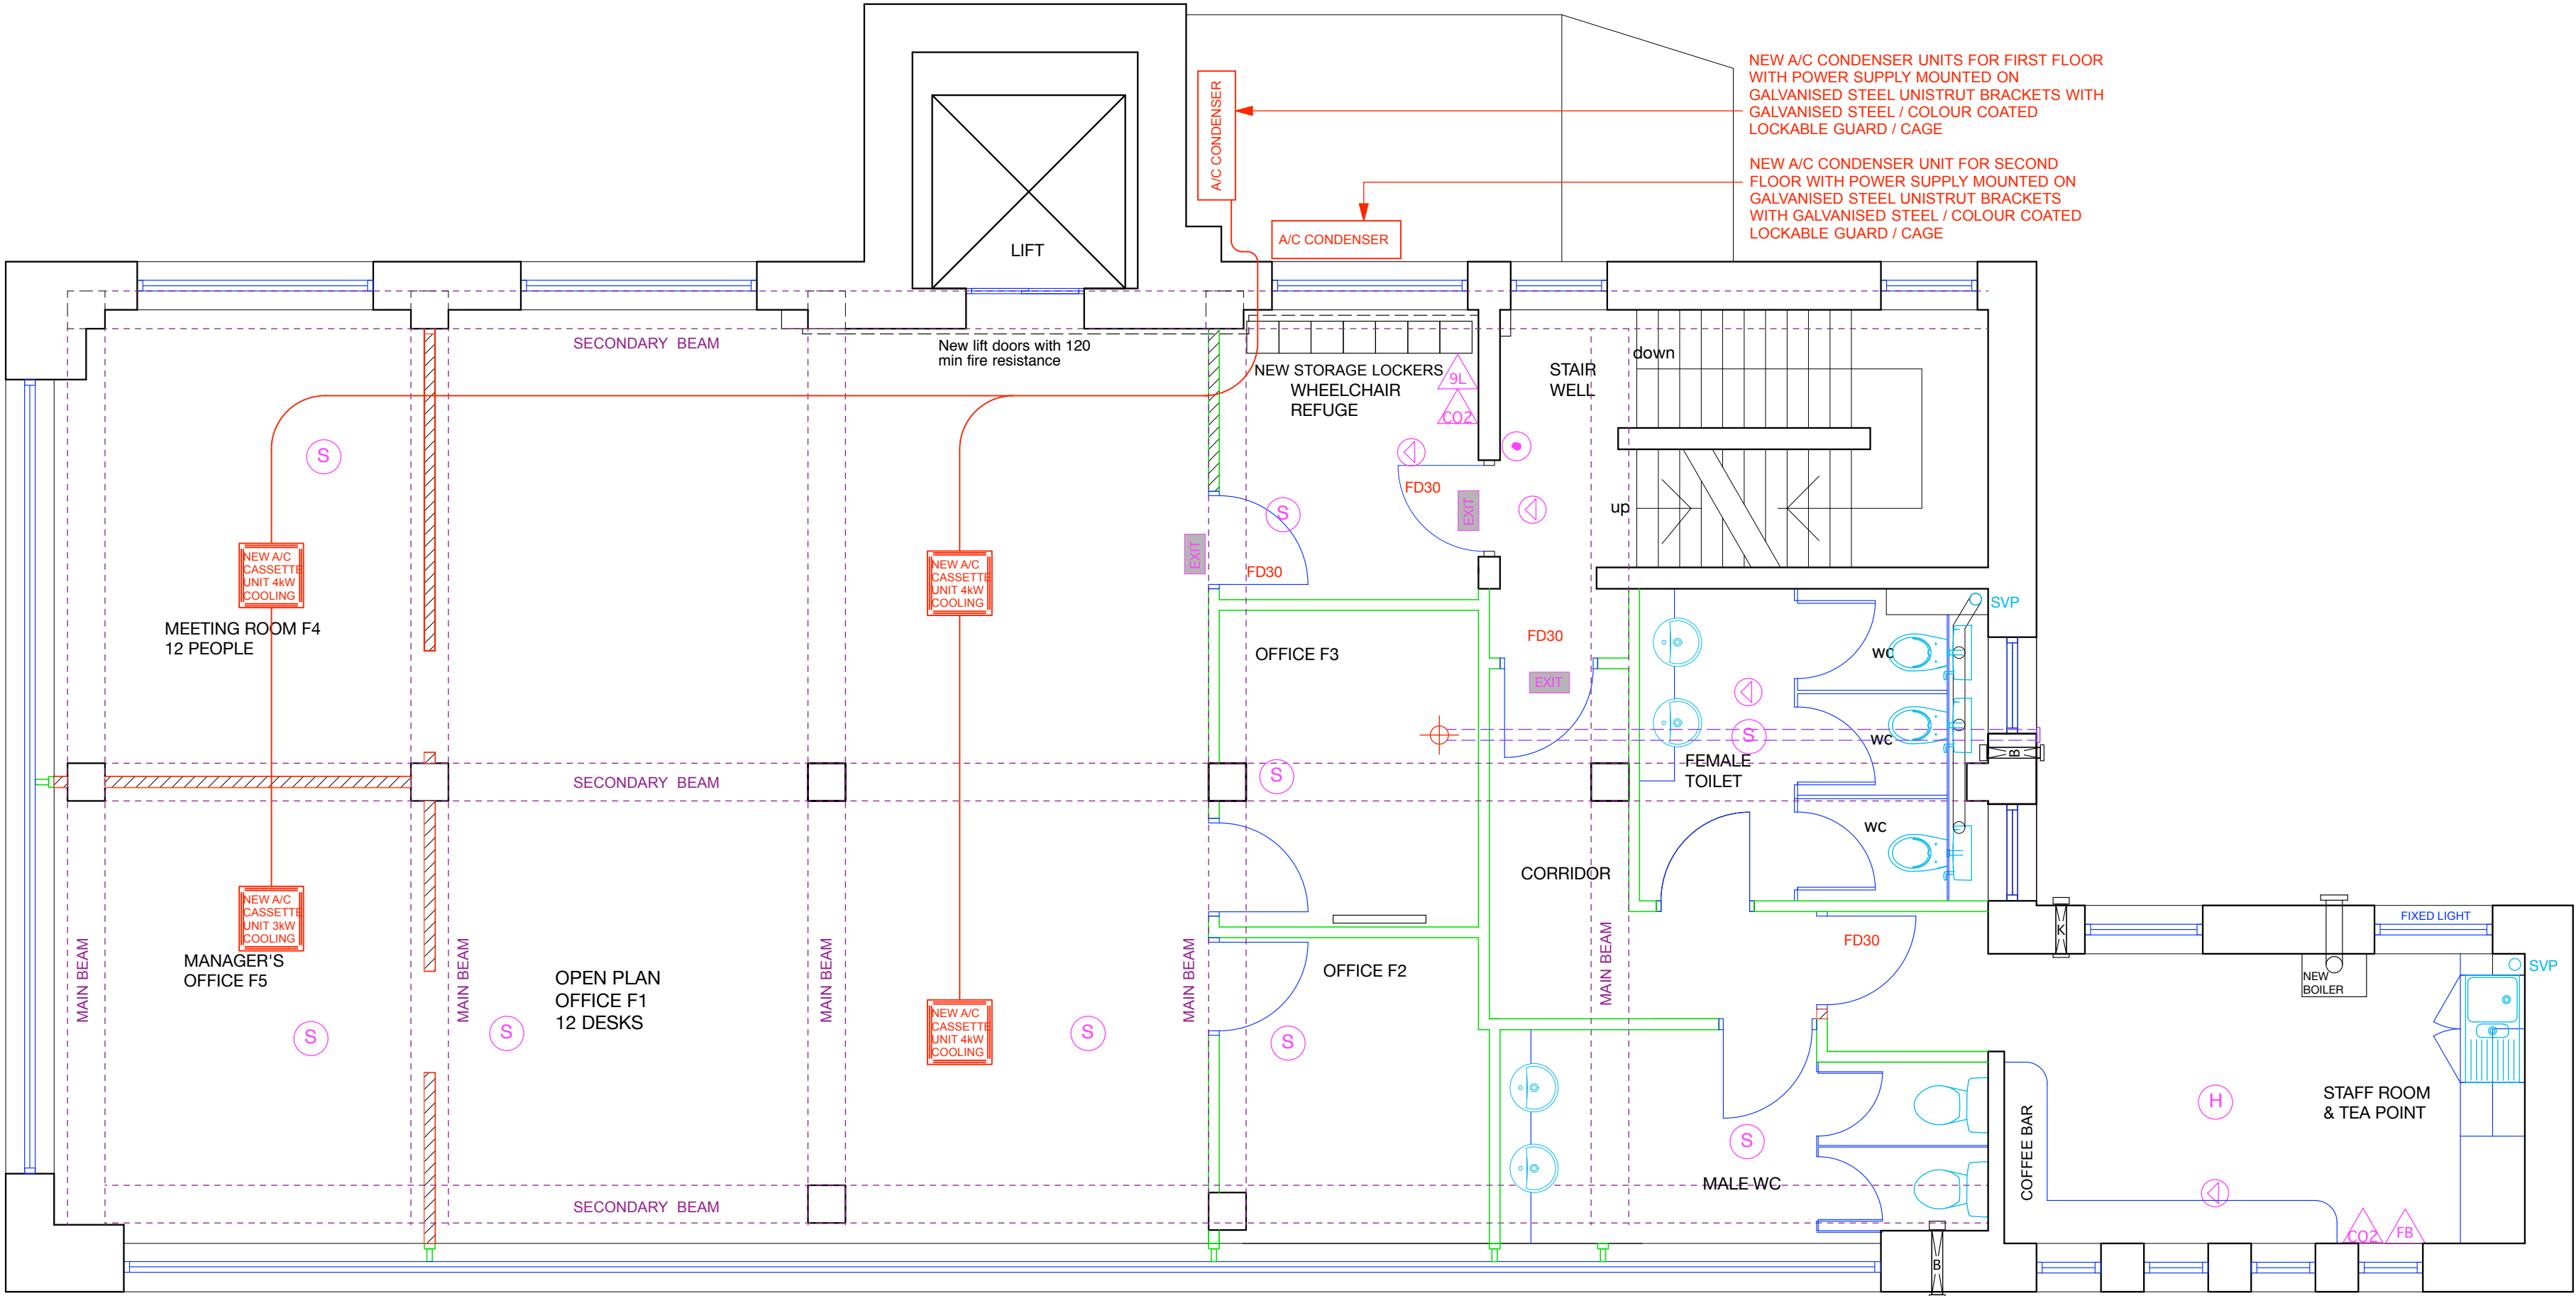

FIRST FLOOR - NEW A/C UNITS

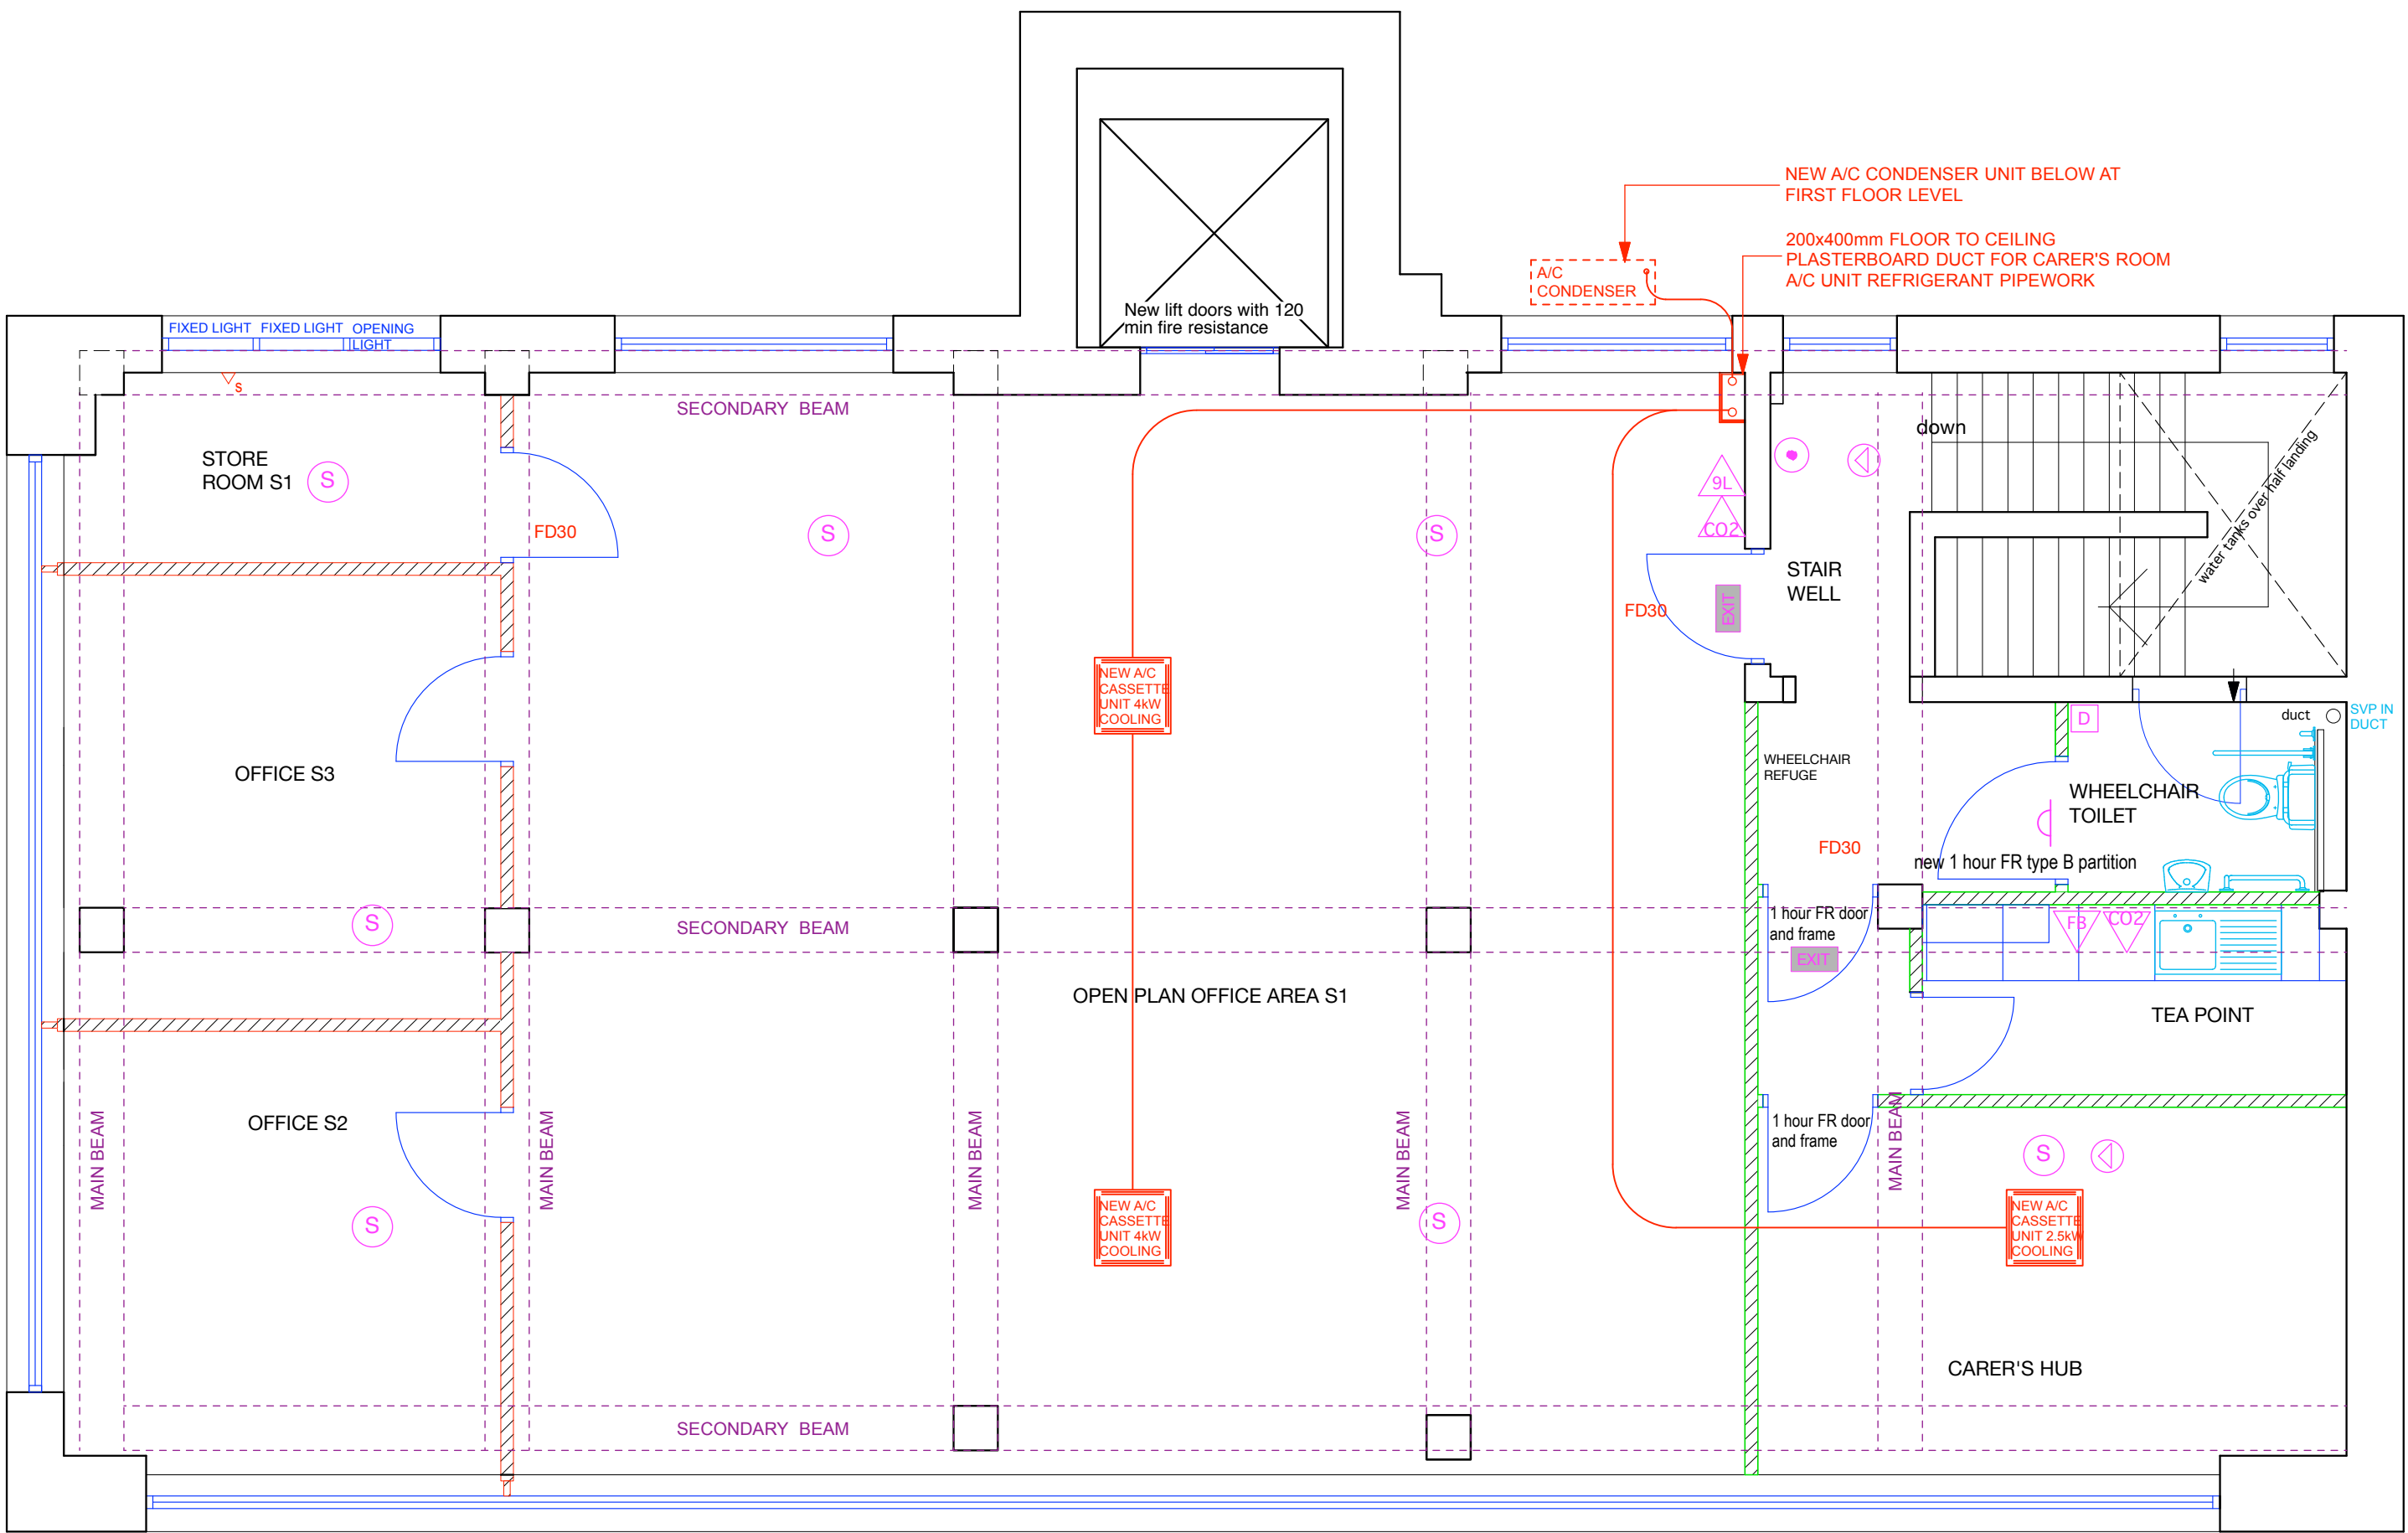

SECOND FLOOR - NEW A/C UNITS

PROPOSED : NEW AIR CONDITIONING UNITS & FIRE STRATEGY
SCALE 1:50

DRAWING STATUS
PLANNING DRAWING

REVISIONS

This drawing, the works and concepts depicted are the copyright of ADJ Architects and may not be reproduced or made use of, either directly or indirectly, without express written consent.
Do not scale off this drawing.
All heights, levels, sizes and dimensions to be checked on site before any work is put to hand.

ADJ Architects
Hopkirk, Eastham, Tisbury, Wiltshire, W13 9AH
andy@adjarchitects.co.uk phone : 077 969 32388

Client
Citizens Advice Merthyr Tydfil

Project
NEW AIR CONDITIONING UNITS

Drawing Title
PROPOSED PLAN : EXTERNAL CONDENSER UNITS

CAD Ref 9071	Drawn ADJ	
Date June 21	Scale 1:50 @ A1	
Project No. 9071	Drawing No. 14	Revision