


Linked Titan TN124 Complex

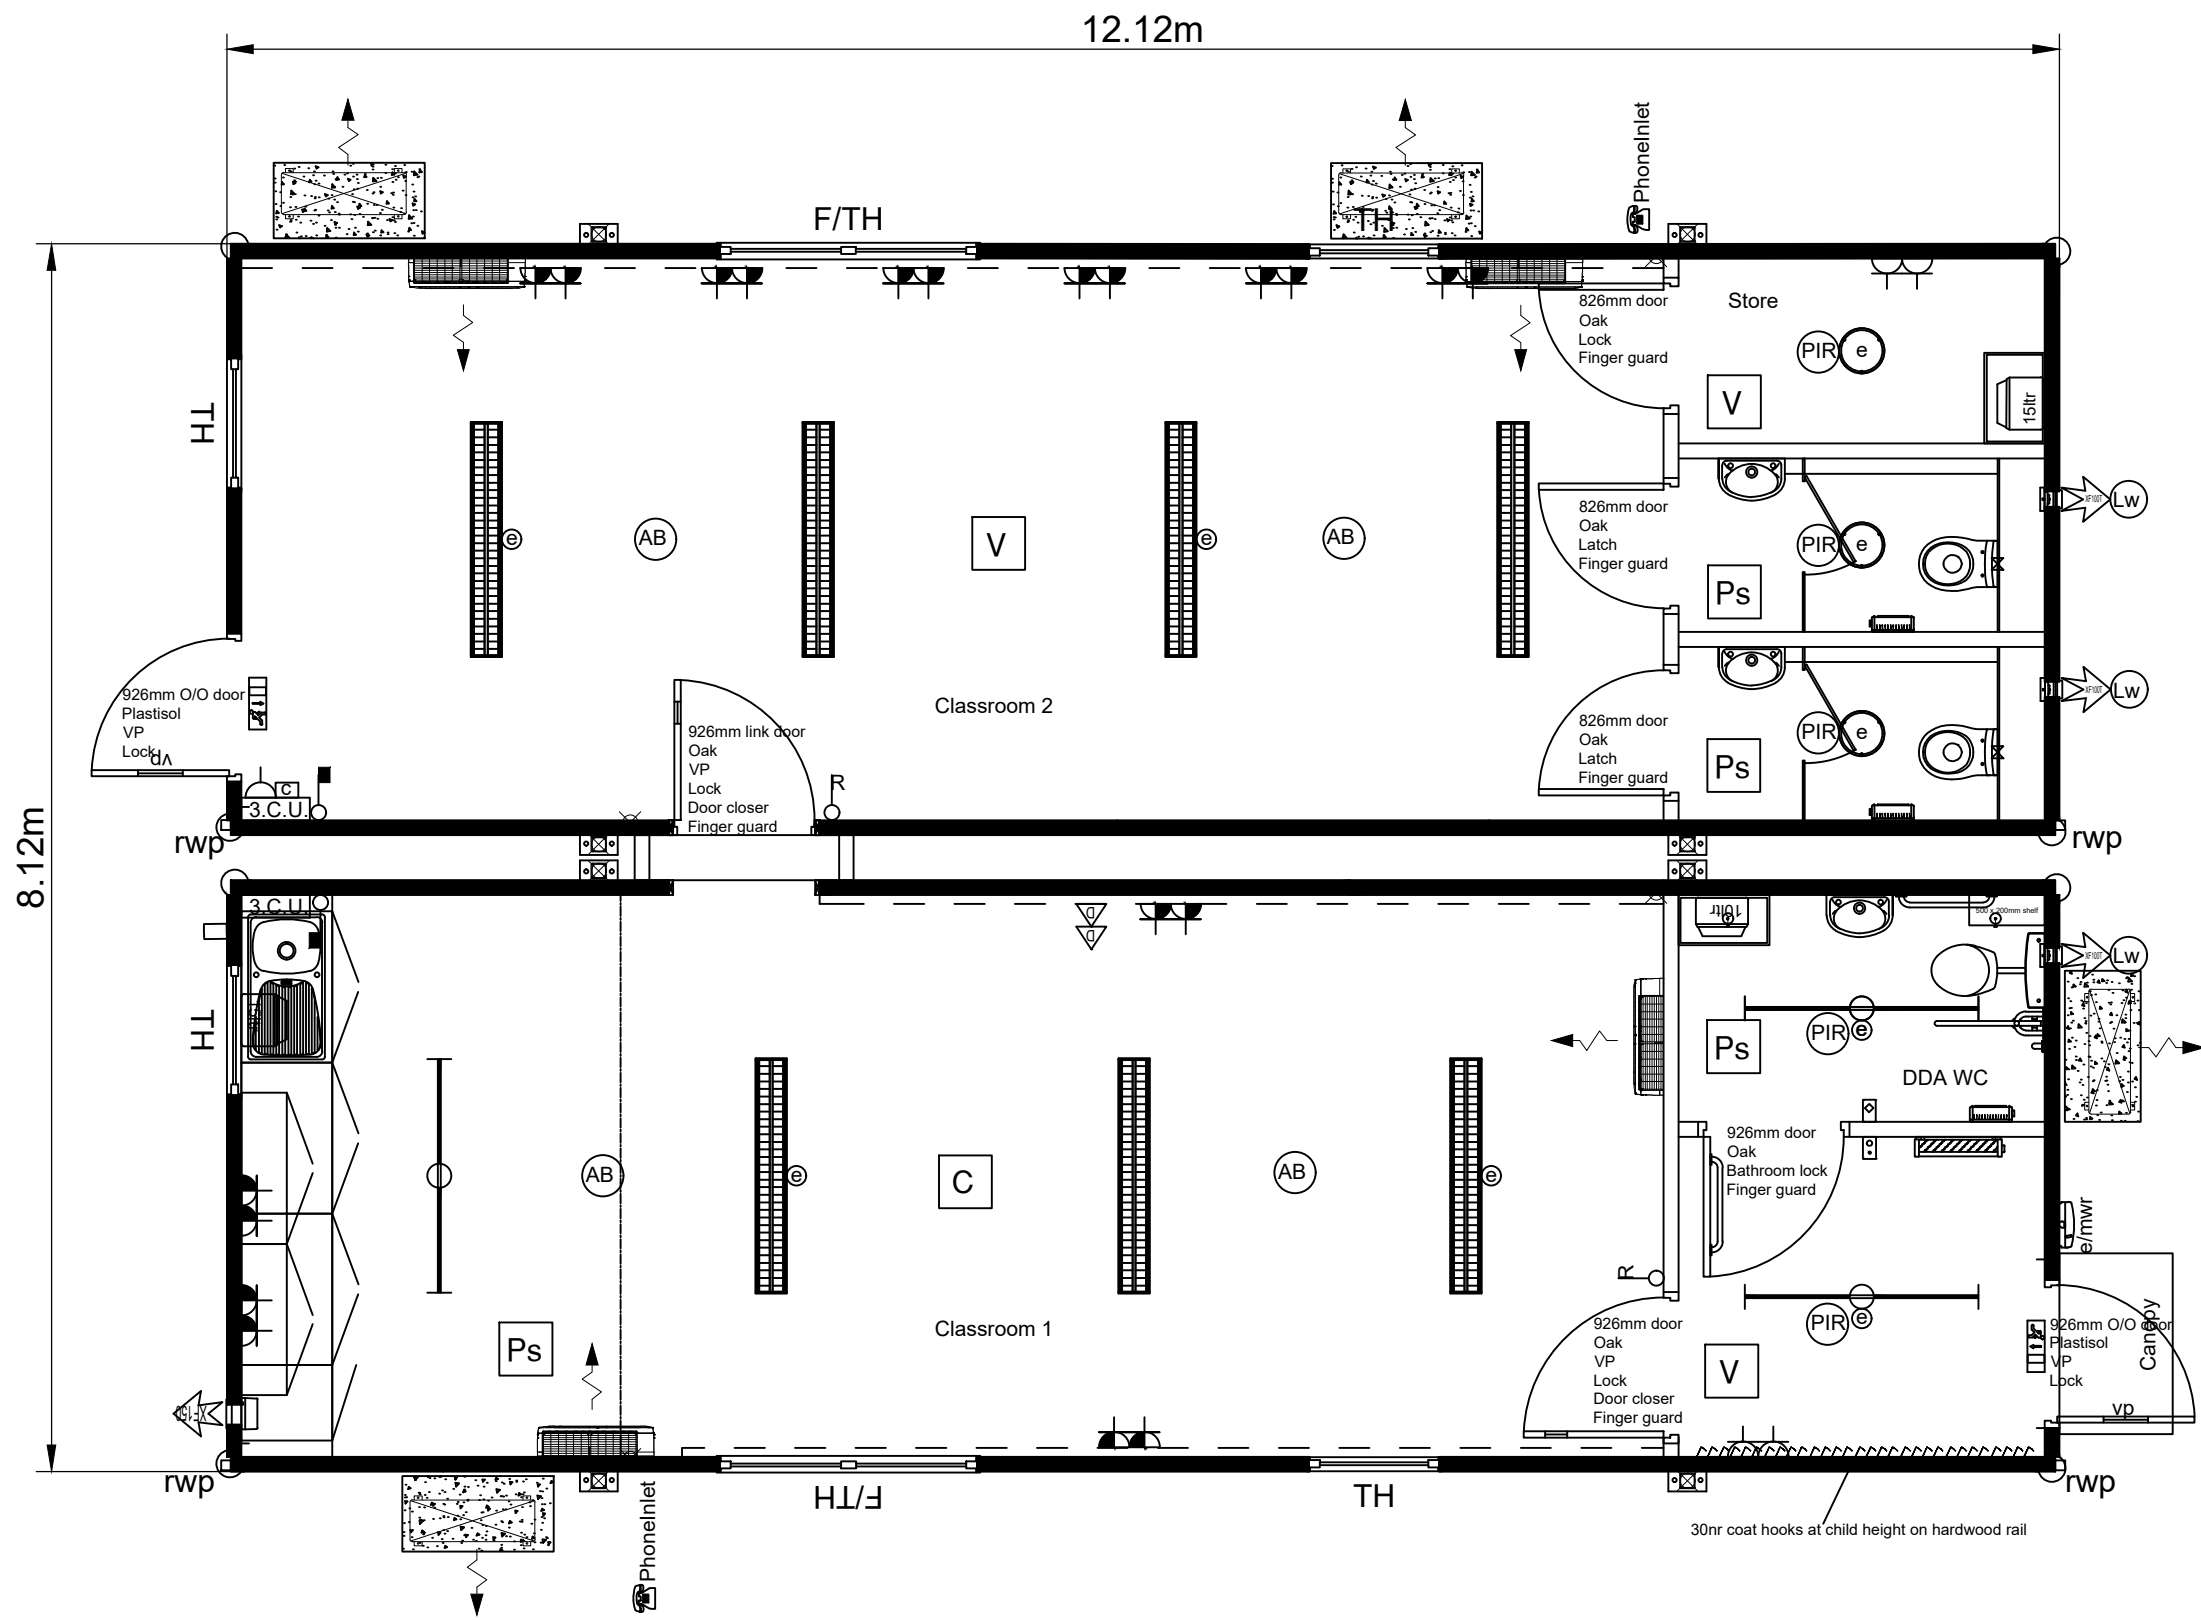

- NOTE:
- BUILDING & LEGS IN HONESTY
 - FASCIA IN TRAFFIC GREY RAL 7042
 - EXTERNAL DOOR PANELS & WINDOW FRAMES IN ANTHRACITE RAL 7016
 - 30 MIN FIRE UPGRADE TO ALL PARTITIONING
 - CARPET TILE FLOORING TO CLASSROOM 1 AREA IN GRAPHITE GREY
 - POLYSAFE NON SLIP VINYL FLOORING TO ALL WET AREAS IN SILVER BIRCH
 - VINYL FLOORING TO CLASSROOM 2 , LOBBY & STORE AREAS IN FLINT GREY
 - FLOOR VINYL FITTED THROUGHOUT IN FLINT GREY
 - LED LIGHTING THROUGHOUT
 - AIR CONDITIONING TO CLASSROOM AREAS
 - ELECTRIC HEATING TO ALL OTHER AREAS APART FROM STORE
 - DOUBLE SWITCH SOCKET & DOUBLE DATA POINTS POSITIONS TBC
 - PUSH TAPS TO CHILDRENS WHB
 - TMV TO ALL OUTLETS INCLUDING KITCHEN SINK
 - KS2 CHILDRENS WC - 350MM HIGH TOILET PANS & BASINS FITTED AT 750MM HIGH
 - HALF HEIGHT IPS IN CHILDRENS WC AREA
 - BOXING IN TO ALL PIPEWORK IN CHILDRENS WC
 - TOILET ROLL HOLDER IN EACH WC
 - MIRRORS ABOVE EACH WHB
 - 2 HOOK MULTIRACK IN DDA WC
 - HARDWOOD COAT RAIL WITH 30 HOOKS AT CHILD HEIGHT IN LOBBY AREA
 - PLUMBING SERVICES THROUGH THE WALL
 - SCHNEIDER 3 PHASE KWH METERING KIT- INCOMING ONLY

- Three phase consumer unit
- Heating controller & spur
- Double data outlet
- 2 gang switched socket
- 2 gang switched socket (mounted above worktop/in dado trunking)
- Retractive light switch
- Adaptable box to facilitate electrical entry

- 1.5m LED light fitting
- 1.5m LED light fitting with emergency light
- 1.5m LED light fitting with emergency light c/w diffuser
- 1.5m LED light fitting c/w diffuser
- LED Bulkhead light fitting c/w emergency light
- LED Bulkhead light fitting c/w emergency and microwave sensor
- 150mm extract fan

- PIR to light (presence)
- Absence detector. (office)
- 3hr, N/M emergency light c/w legend
- Emergency light key test switch
- 2KW convector heater
- 2kw H/L fan Heater
- 100mm low wattage extract fan c/w time delay

- Indicative position split A/C system - Condenser unit (External)
- Indicative position split A/C system - Evaporator unit (Internal)
- Polysafe vinyl flooring in Silver Birch
- Vinyl flooring in Flint Grey
- Carpet Tile Flooring in Graphite Grey
- 3 compartment trunking

- Assistance alarm pull cord
- Assistance alarm overdoor lamp
- Assistance alarm reset (1200aff)
- 10 litre unvented water heater
- 15 litre unvented water heater

Floor Area 89.00 m²
Ceiling Height 2.5 m

Window Key
TH = Top Hung
F/TH = Fixed / Top Hung

Rev	Item	Name	Date
A	Widened partition to store & childrens WC's. Changed childrens WC door bathroom locks to latches. Added internal cubicle door to childrens WCs.	L Hodgson	19/05/21
B	Added retractive light switches. Amended notes.	L Hodgson	24/05/21
C	Removed standalone fire & intruder alarm notes.	L Hodgson	25/05/21
D	Changed complex to 2nr TN124. Added link.	L Hodgson	08/06/21
E	External cable box added. AC condenser dropped down. Telephone inlet moved to front elevation of Classroom 1. 30nr hooks added in lobby. RWP positions moved. Convector heater moved to DDA WC partition wall.	L Hodgson	17/06/21

Portakabin

Portakabin Limited Huntington York YO32 9PT
Telephone 01904 611655 Fax 01904 611644

Project GREENFIELD SCHOOL		
Client Merthyr Tydfil Council		
Title Floor Plan 2nr Linked TN124 400015583	Date 13/05/2021 Scale 1:50 @ A2 Drg. No. OPP1243663	Drawn L Hodgson Rev. E