


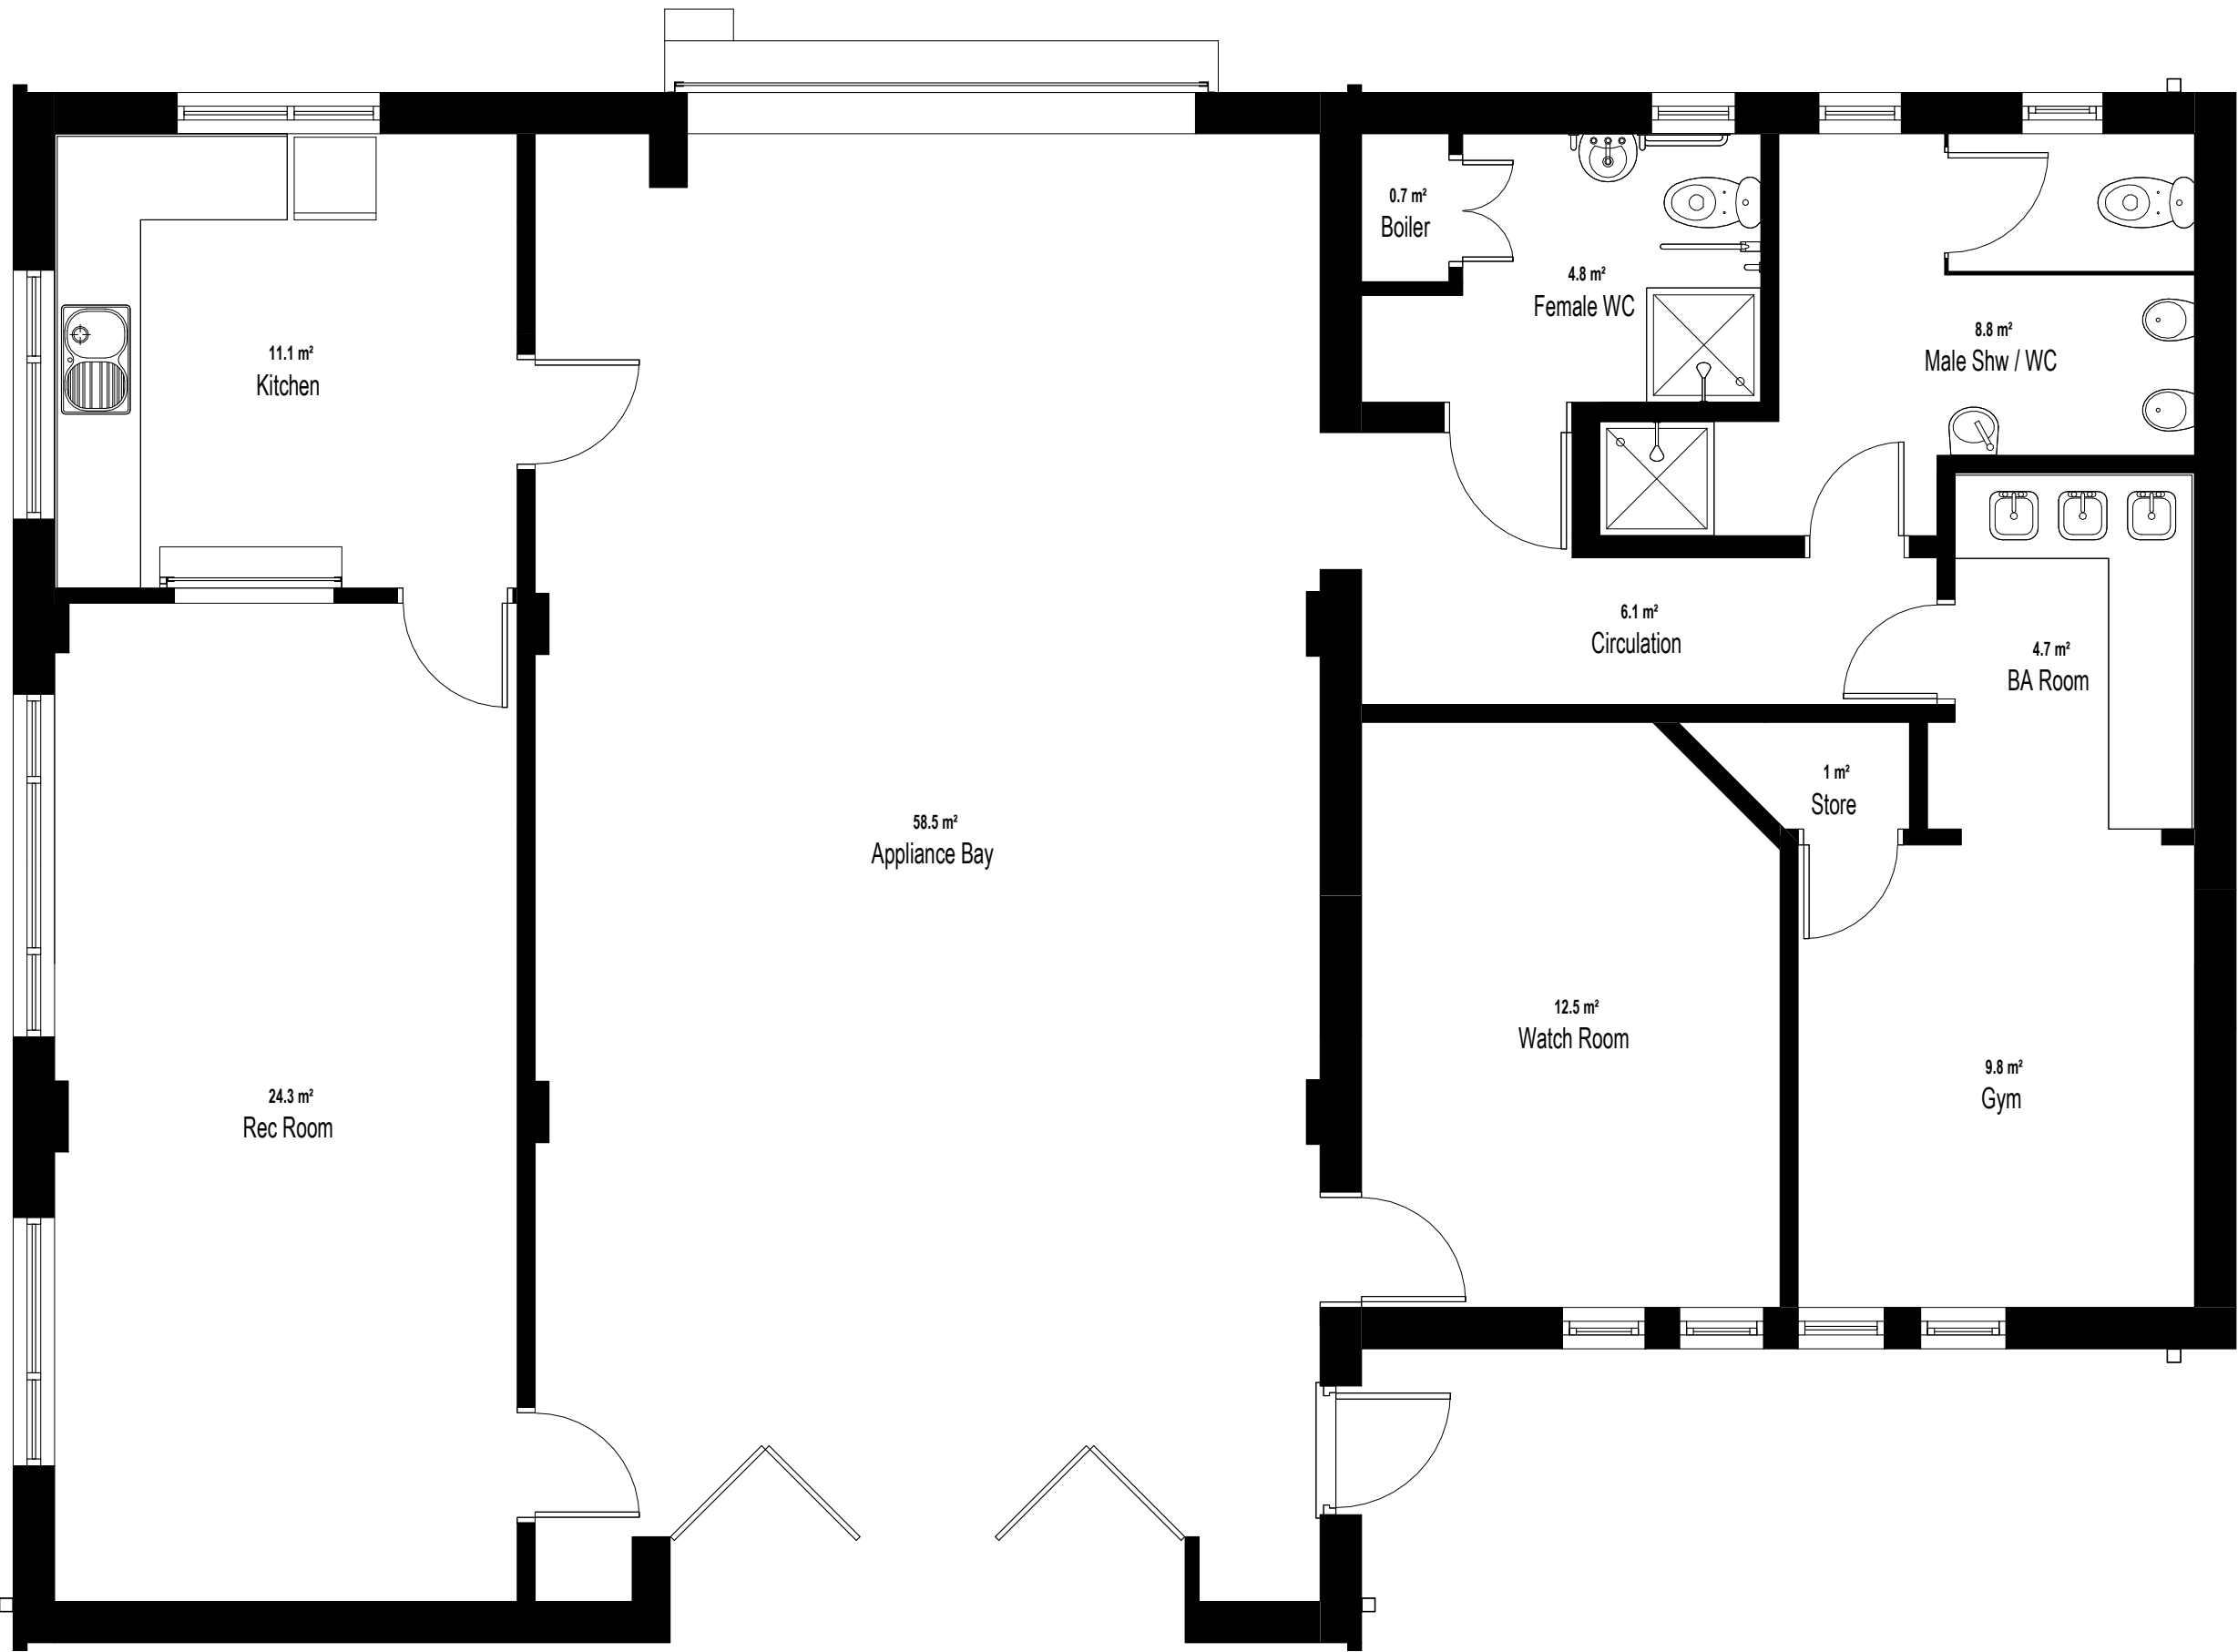

G00 - Existing Ground
1 : 50

P01	Issued for Planning HD HD KJ	07/07/2022
P00	First Issue HD KJ CE	05/01/2020
REV	DESCRIPTION DRAWN BY CHECKED BY APPROVED BY	DATE
RIBA PLAN OF WORK 2013 WORKSTAGE	LEVEL OF MODEL DEFINITION (LoD)	
Stage 3 - Developed Design	LoD 3 - Approximate Model	
PURPOSE OF ISSUE - SUITABLE FOR ...	BS1192 STATUS	
Planning Submission	Status S2 - Information	

lawrayarchitects
penseiri

CARDIFF029 2052 8140
LONDON0207 138 3560
WREXHAM01978 357 887
www.lawray.co.uk

CLIENT
South Wales Fire & Rescue Service

PROJECT TITLE
Treharris Fire Station

DRAWING TITLE
Existing Ground Floor Plan

PROJECT No 19413		SCALE @ A2 1 : 50	
DRAWING No (BS1192:2007 +A2:2016) & BS EN ISO19650	PROJECT - ORIGINATOR - VOLUME - LEVEL - TYPE - ROLE - NUMBER TH-LAW-X-G00-DR	A-031001	REVISION P01
DO NOT SCALE	Any discrepancy or query concerning this drawing should be referred to the Architect Copyright © LAWRAY LIMITED Registered Office: Greenmeadow Springs, 1 Cae Gwyrdd, Tongwynlais, CARDIFF CF15 7AB Reg. Co. No. 2724178, VAT Reg. No. 134 2146 06		