 



Ysgol Rhyd y Grug

Existing Building Layout

Symbol	Quantity	Article number	Article name
	30	AME2 NM3 LE3	A1
	11	OPUCL L70 W C727	O1
	49	OPUWP L15 AS C727	W1

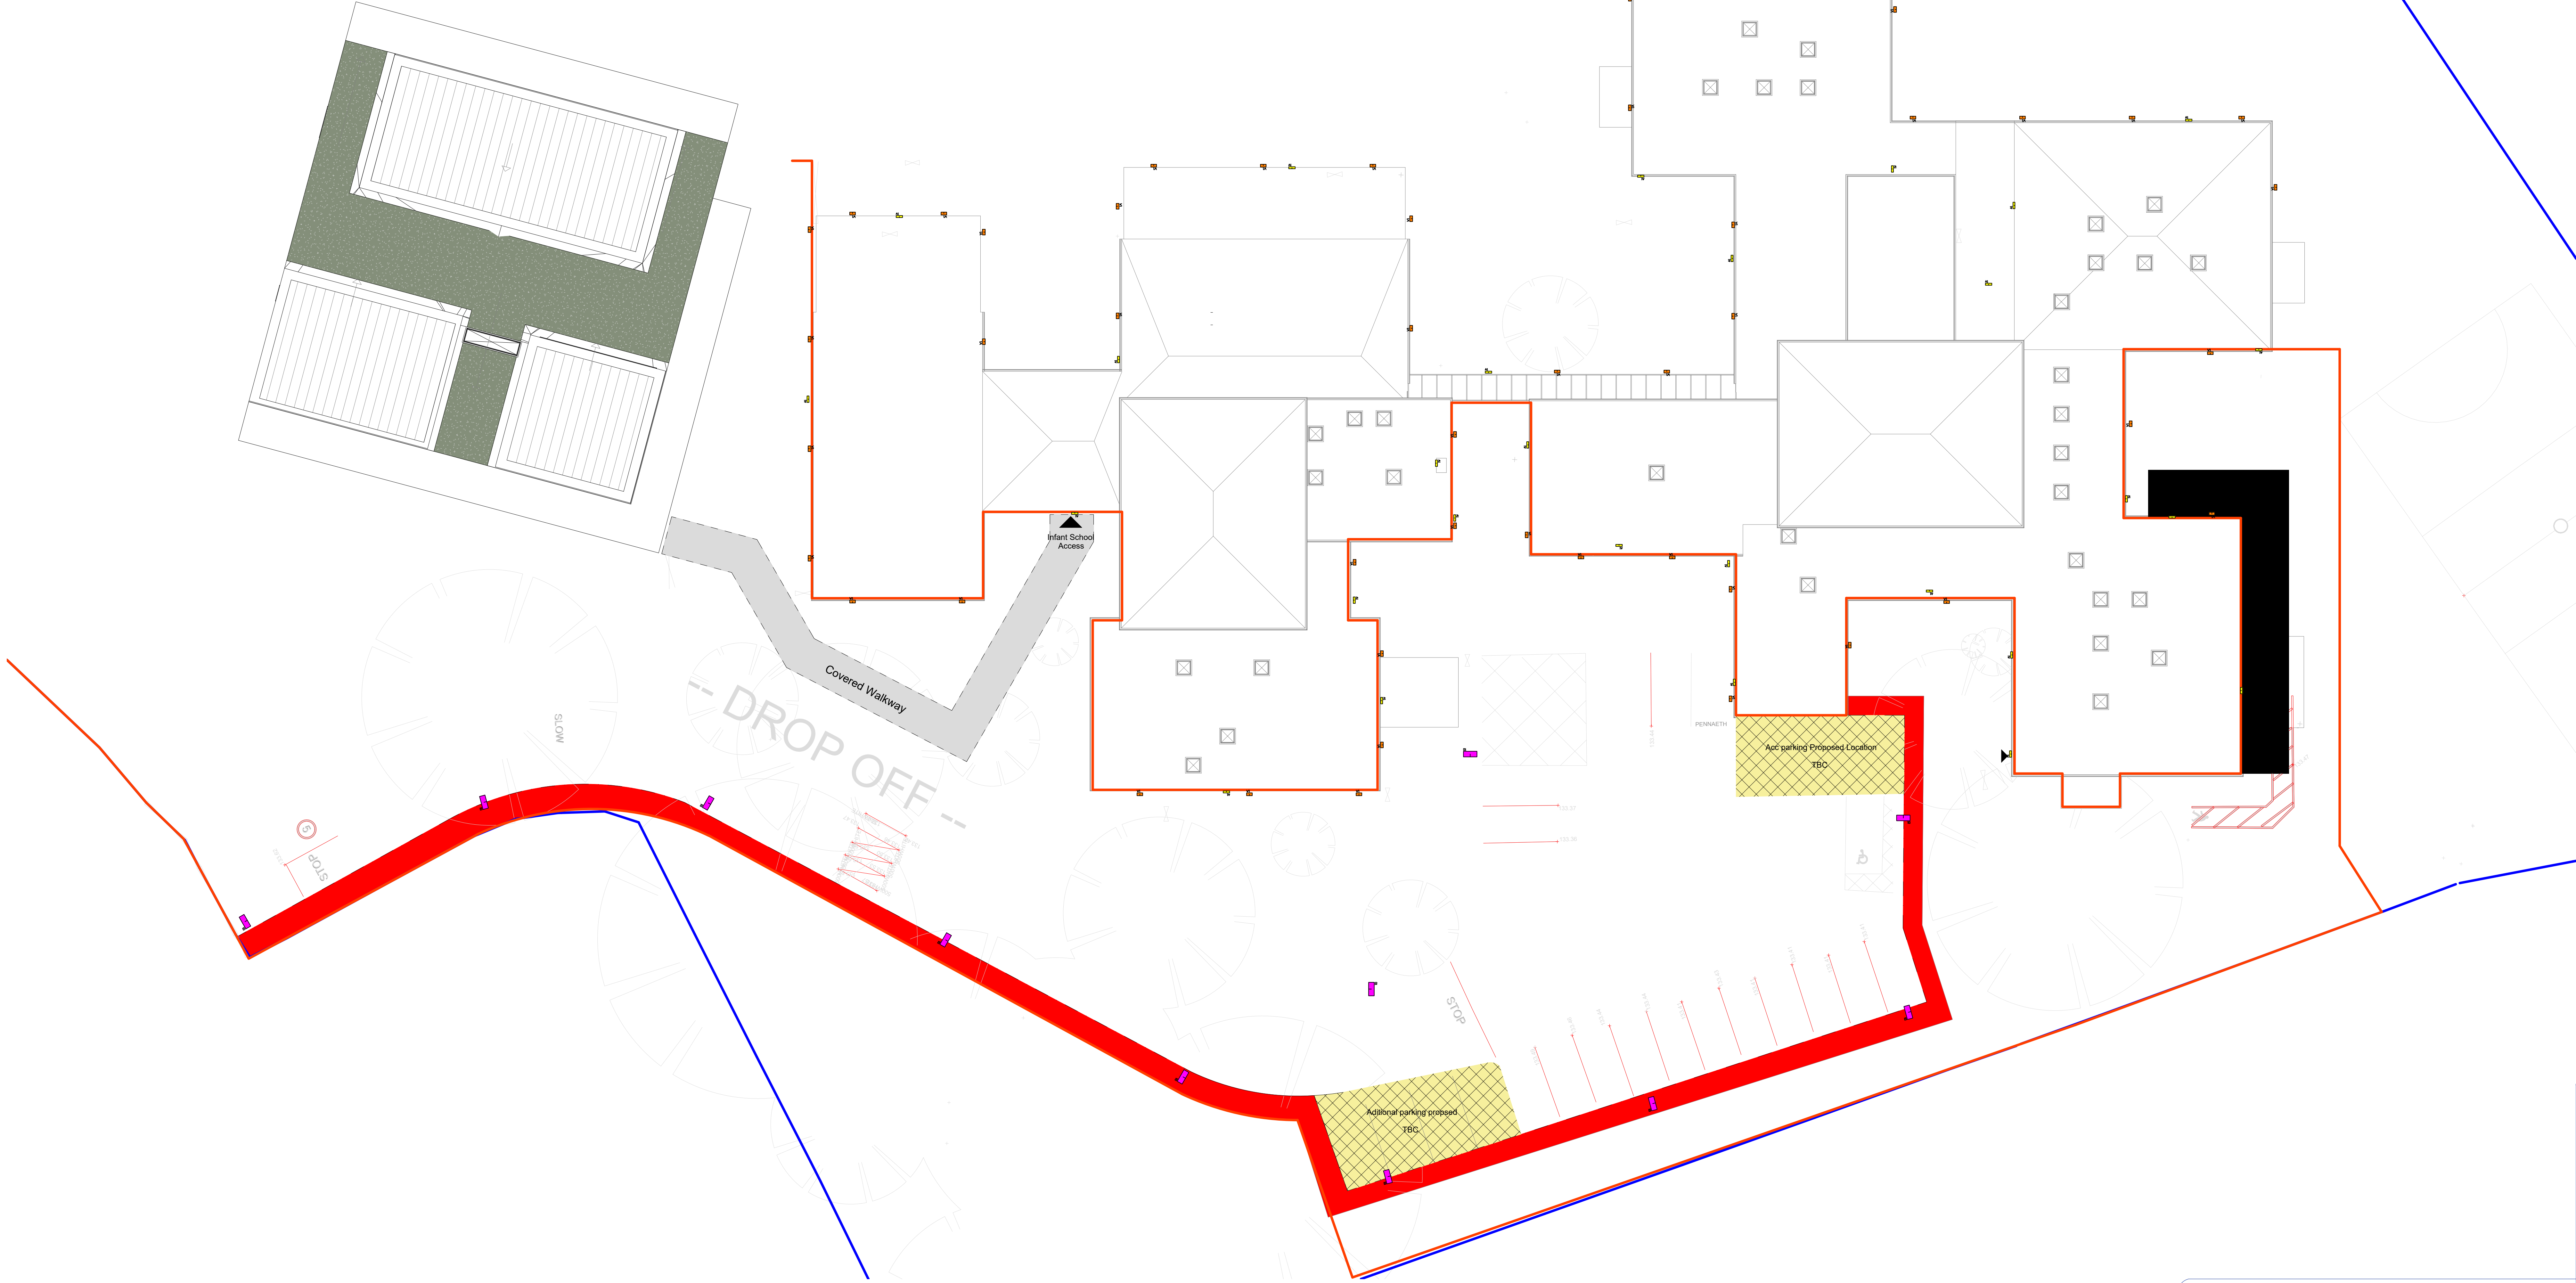

Lighting design layout has been performed according to current standards, information supplied prior to commencing design and good design practice.
Onsite conditions, reflectance values, unknown obstructions, performance of specific components and assumptions made by Engineers may cause differences between calculated and measured and as-drawn values.
Dextra Group PLC will NOT accept any responsibility for the indicative emergency layout.
This drawing is for indicative purposes and Dextra Group PLC will NOT be held responsible for any decisions in either design or specific onsite complications.
PDF conversions to CAD drawings may not be dimensionally accurate.

Scheme No: 654437
Project: Ysgol Rhyd y Grug
Description: External Lighting Design Layout
File Name: 05437-Ysgol Rhyd y Grug-Existing Building- Lighting Layout
Customer: ---

Rev: B
Dm: GT
Checked: JT
Date: 31/03/2025
Scale: 1:150
A0

NOTES: