
 

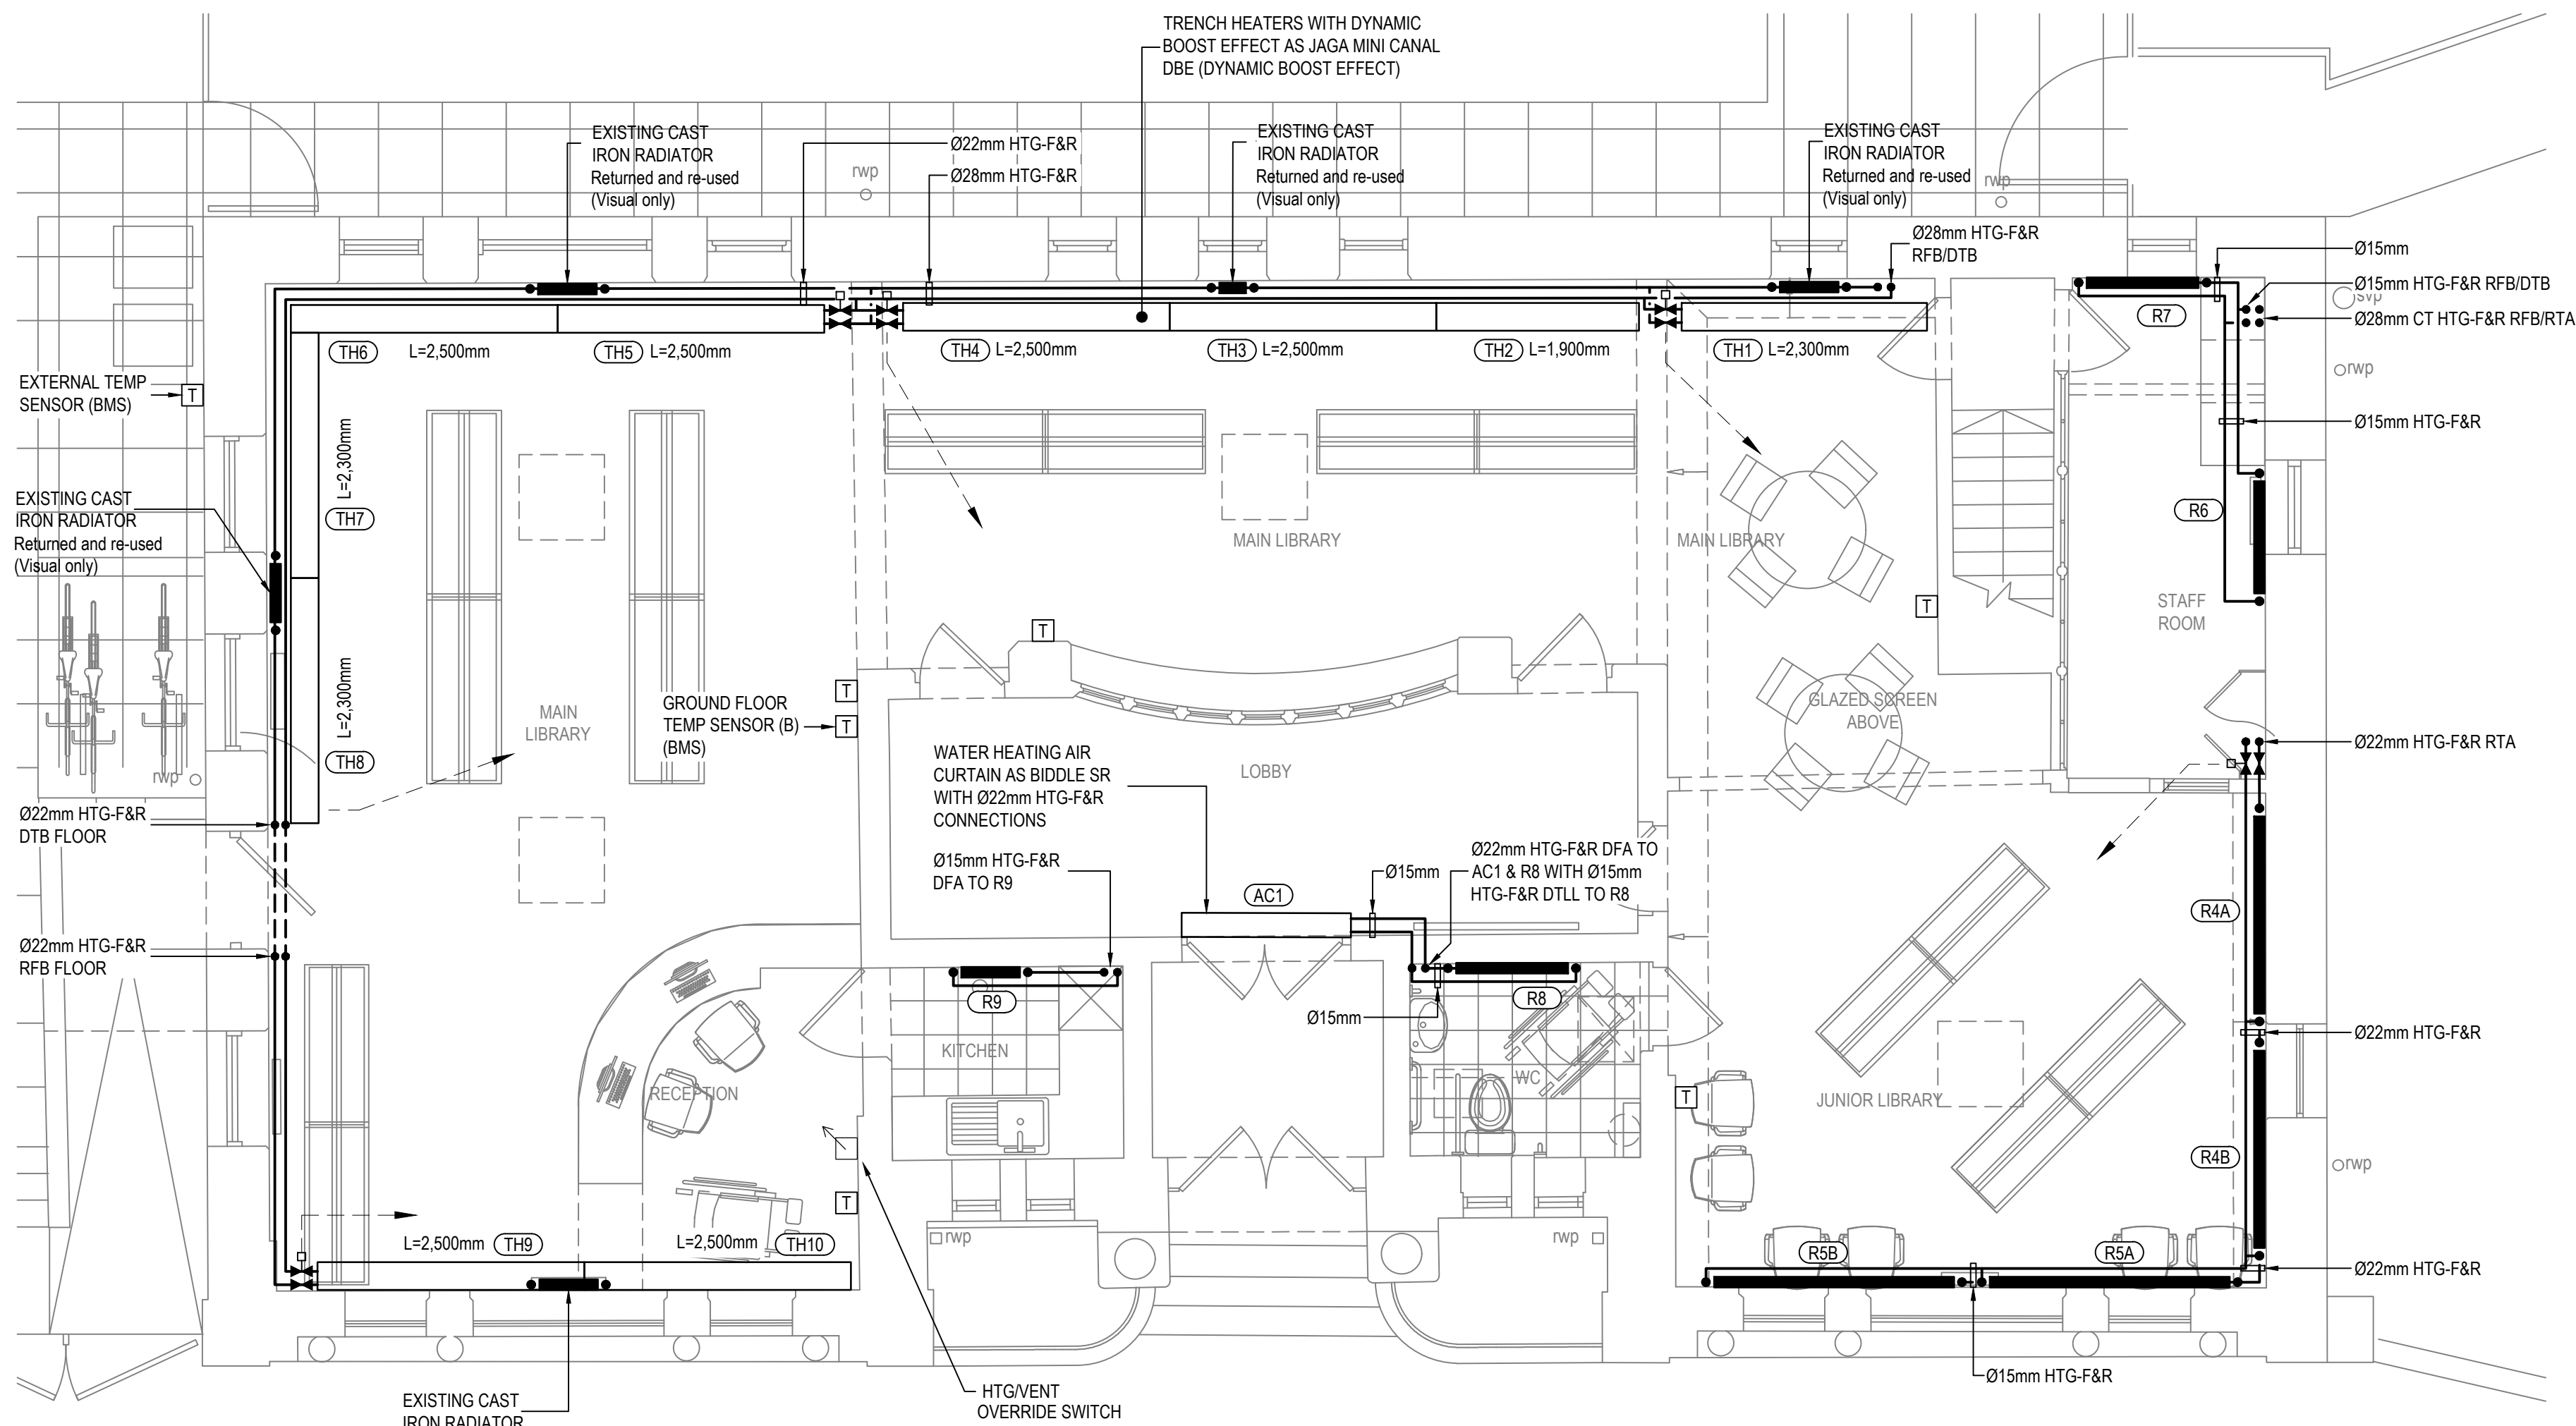




GROUND FLOOR
SCALE 1:50

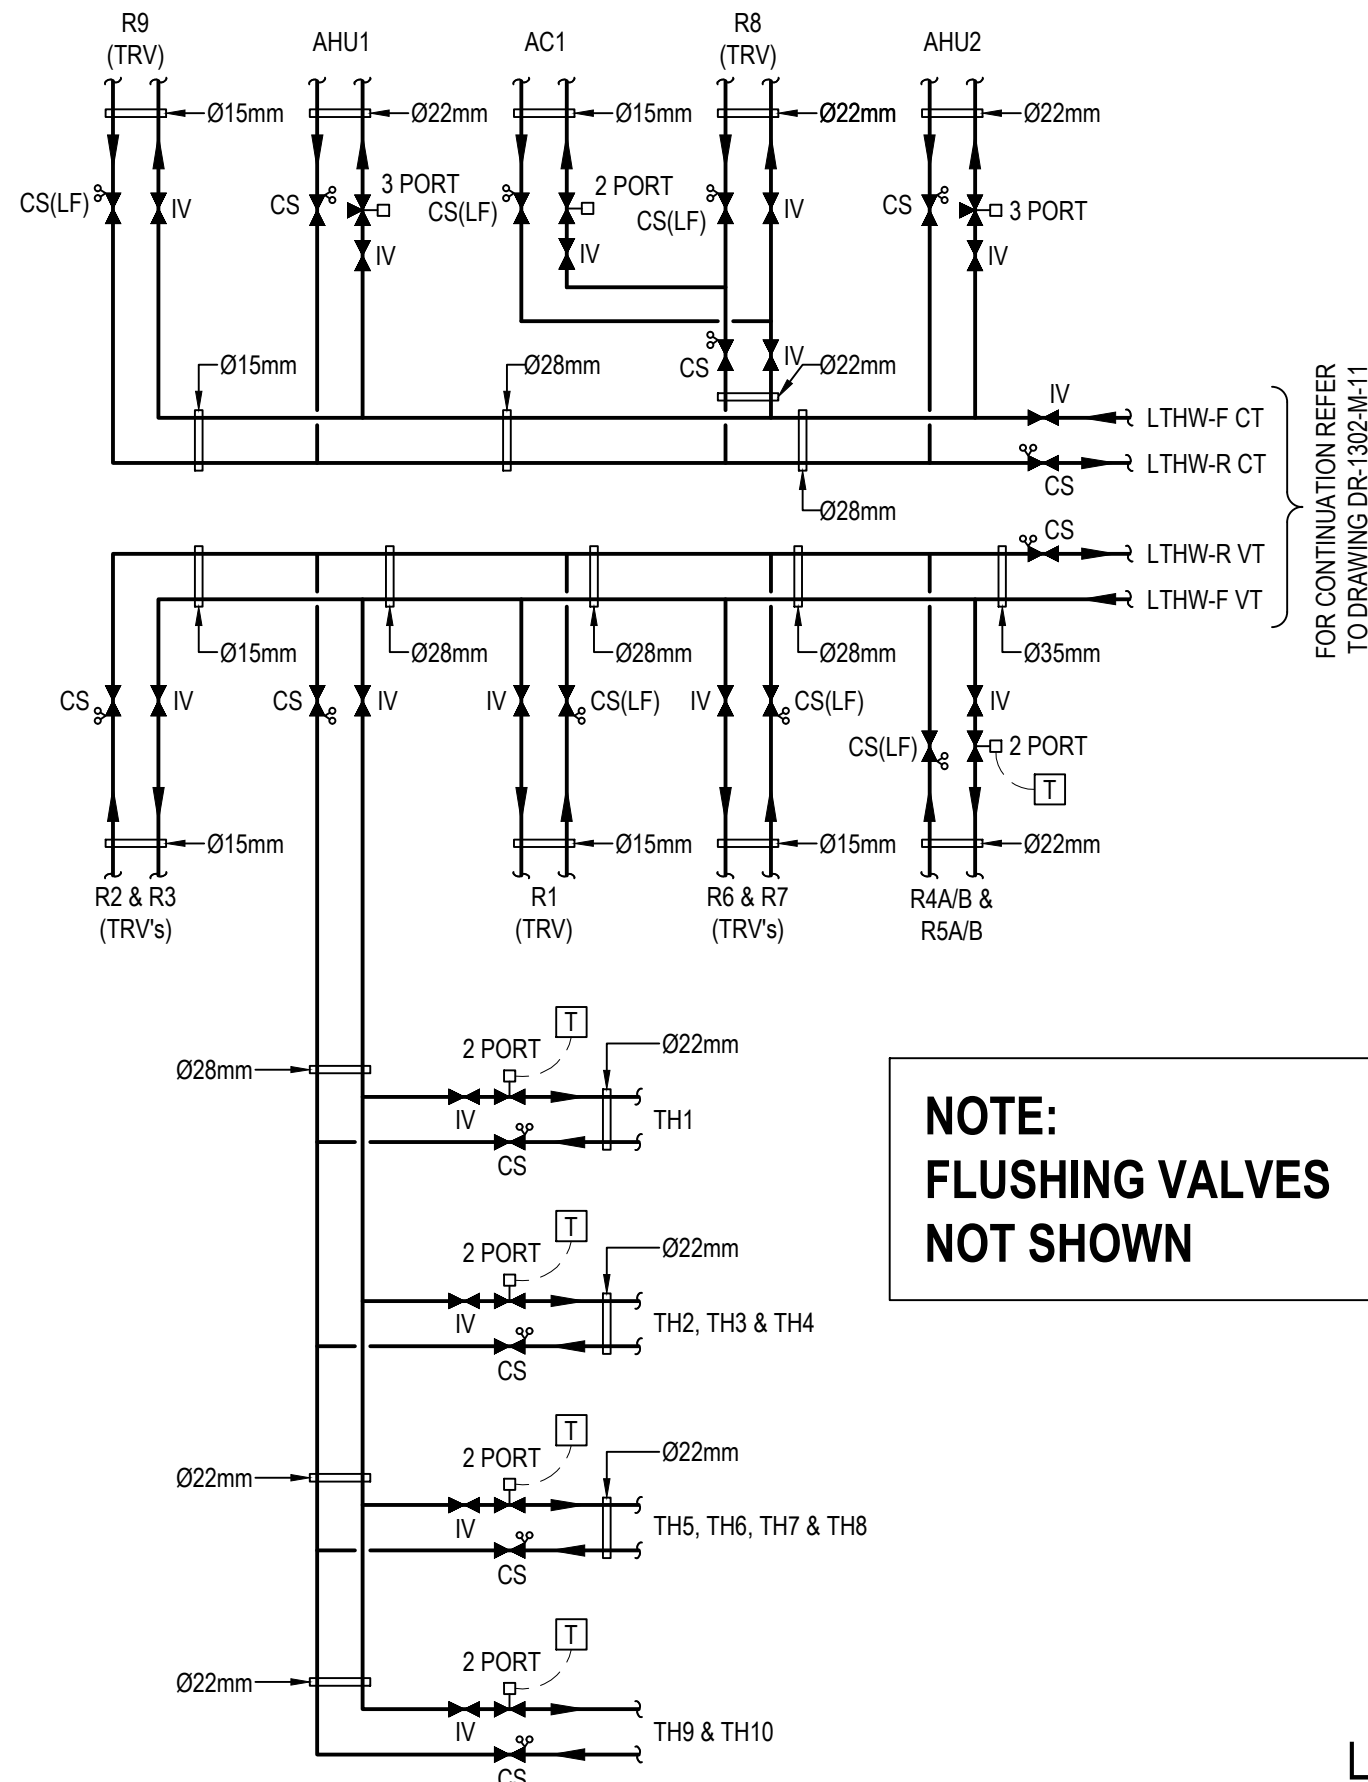

**NOTE:
FLUSHING VALVES
NOT SHOWN**

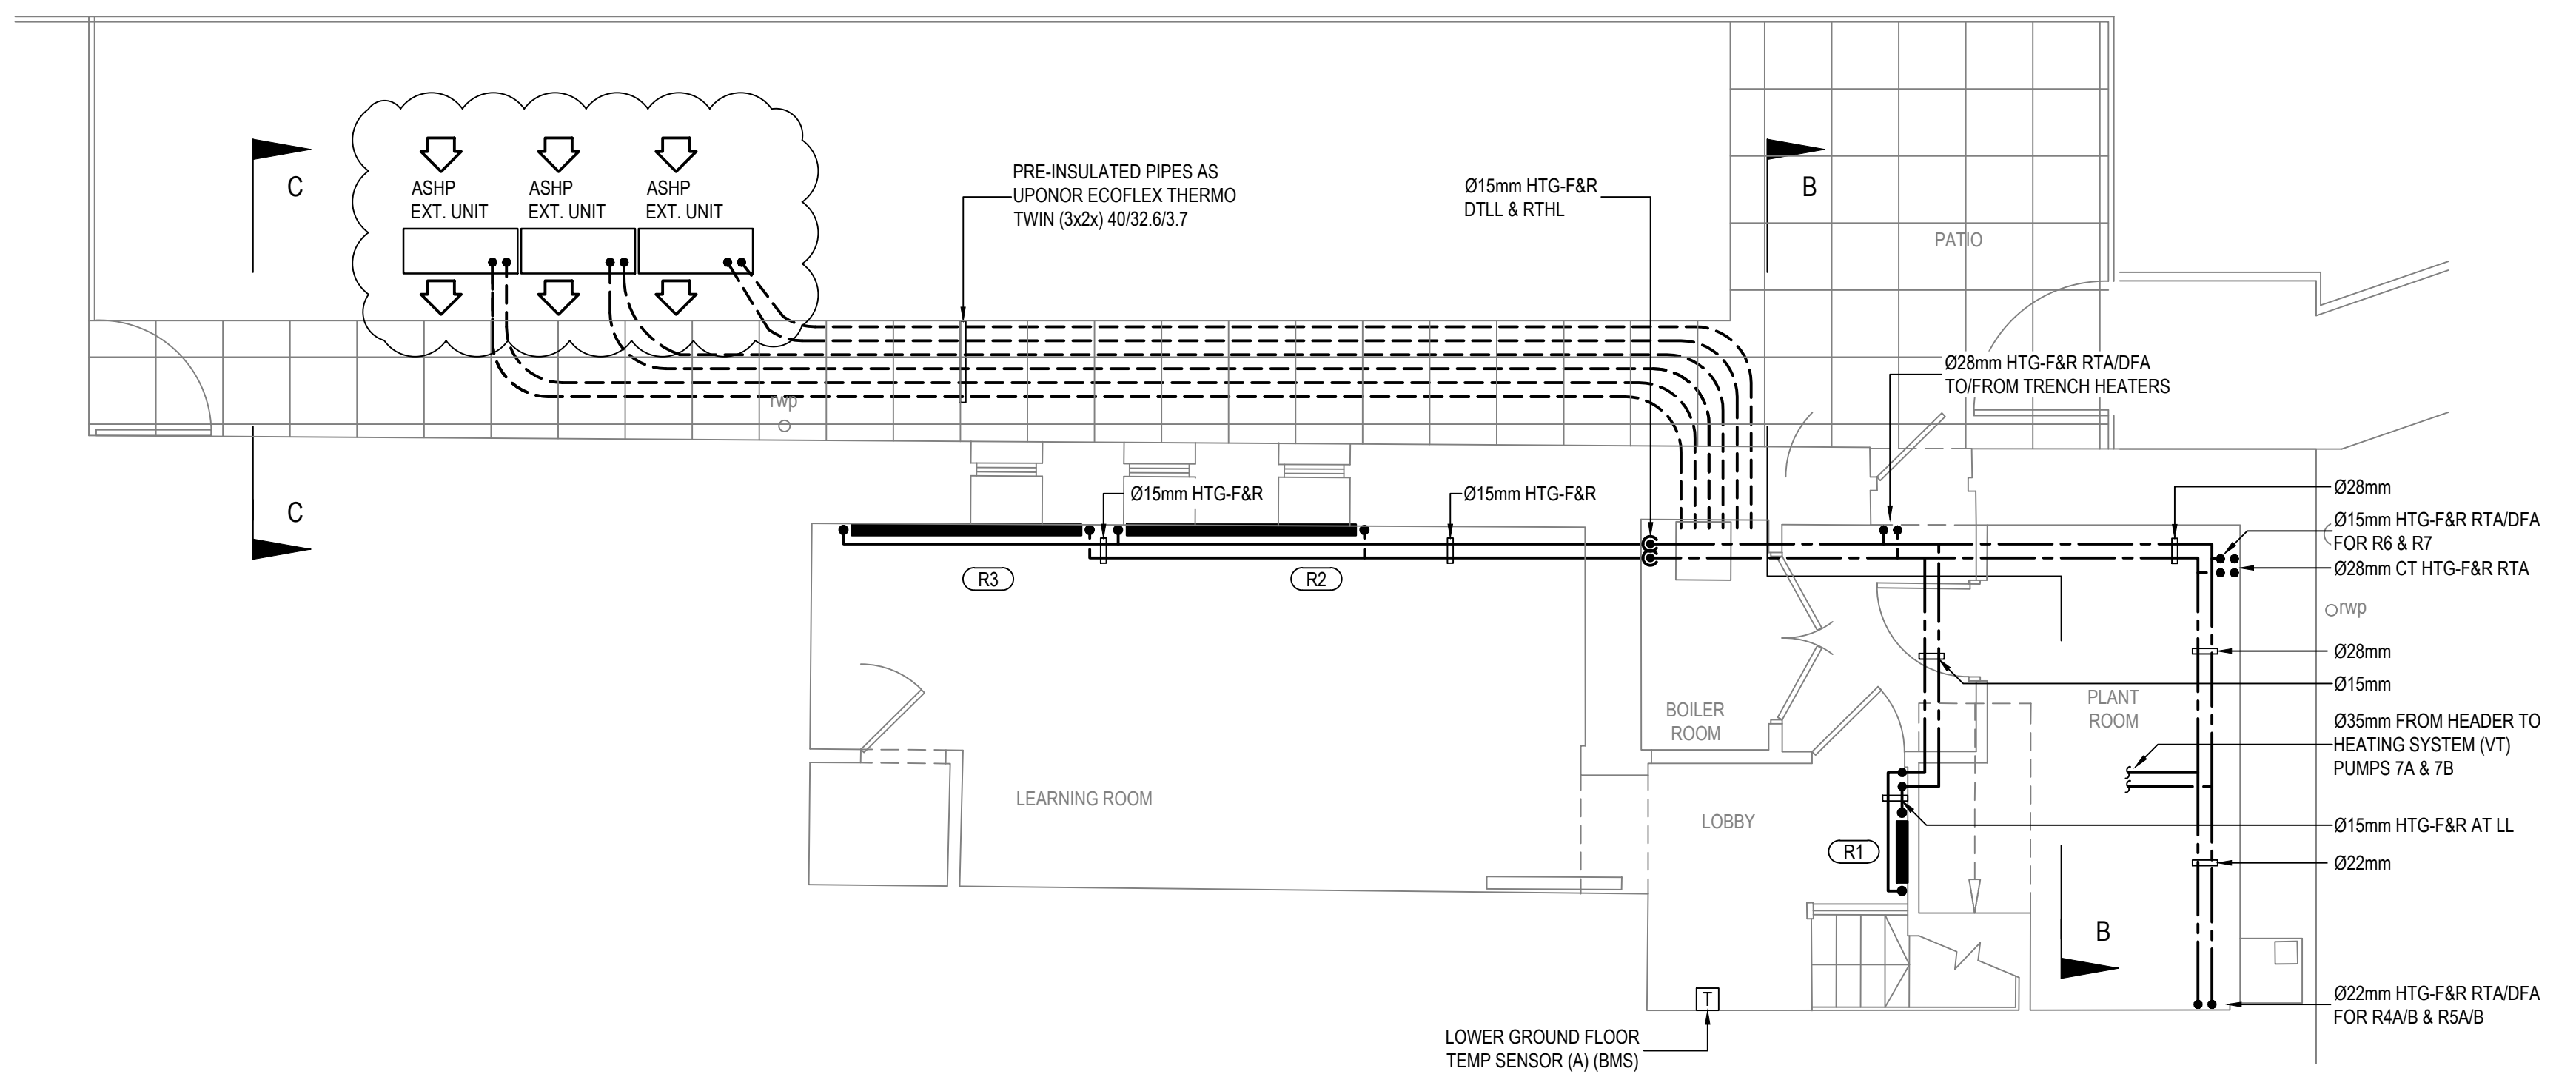

LOWER GROUND FLOOR

SCALE 1:50

TENDER ISSUE						
T2	ASHP COMPOUND OMITTED	RW	KS	09.10.23		
T1	TENDER ISSUE	KS	RW	02.05.23		
T0	TENDER ISSUE	KS	RW	28.04.23		
REV	DESCRIPTION	CHK	APP	DATE		

Client:

MERTHYR TYDFIL COUNTY
BOROUGH COUNCIL
CIVIC CENTRE, CASTLE STREET,
MERTHYR TYDFIL, CF47 8AN



4 Ty Nant Court,
Morganstown,
Cardiff,
CF15 8LW



T: 02920 811266
F: 02920 814459
W: www.dracconsulting.com

Project:
TREHARRIS LIBRARY

Drawing Title:
PROPOSED LOWER GROUND FLOOR
& GROUND FLOOR
HEATING LAYOUT

Scale @ A1 1:50	Drawn M.P.	Checked K.S.	Approved R.W.	Date 28.04.23
Drawing No. DR-1302-M-06				Revision T2