



- NOTES :
- DO NOT SCALE: CONTRACTOR TO CHECK ALL DIMENSIONS AND REPORT ANY OMISSIONS OR ERRORS
  - ALL DIMENSIONS ARE IN MILLIMETRES, UNLESS NOTED OTHERWISE
  - THIS DRAWING IS NOT FOR INSTALLATION PURPOSES. DESIGN, INSTALLATION AND CO-ORDINATION DRAWINGS SHALL BE PROVIDED BY THE CONTRACTOR IN ACCORDANCE WITH THE SPECIFICATION. THE CONTRACTOR IS TO READ THIS DRAWING IN CONJUNCTION WITH THE HEALTH AND SAFETY PLAN AND DESIGN HAZARD INFORMATION.

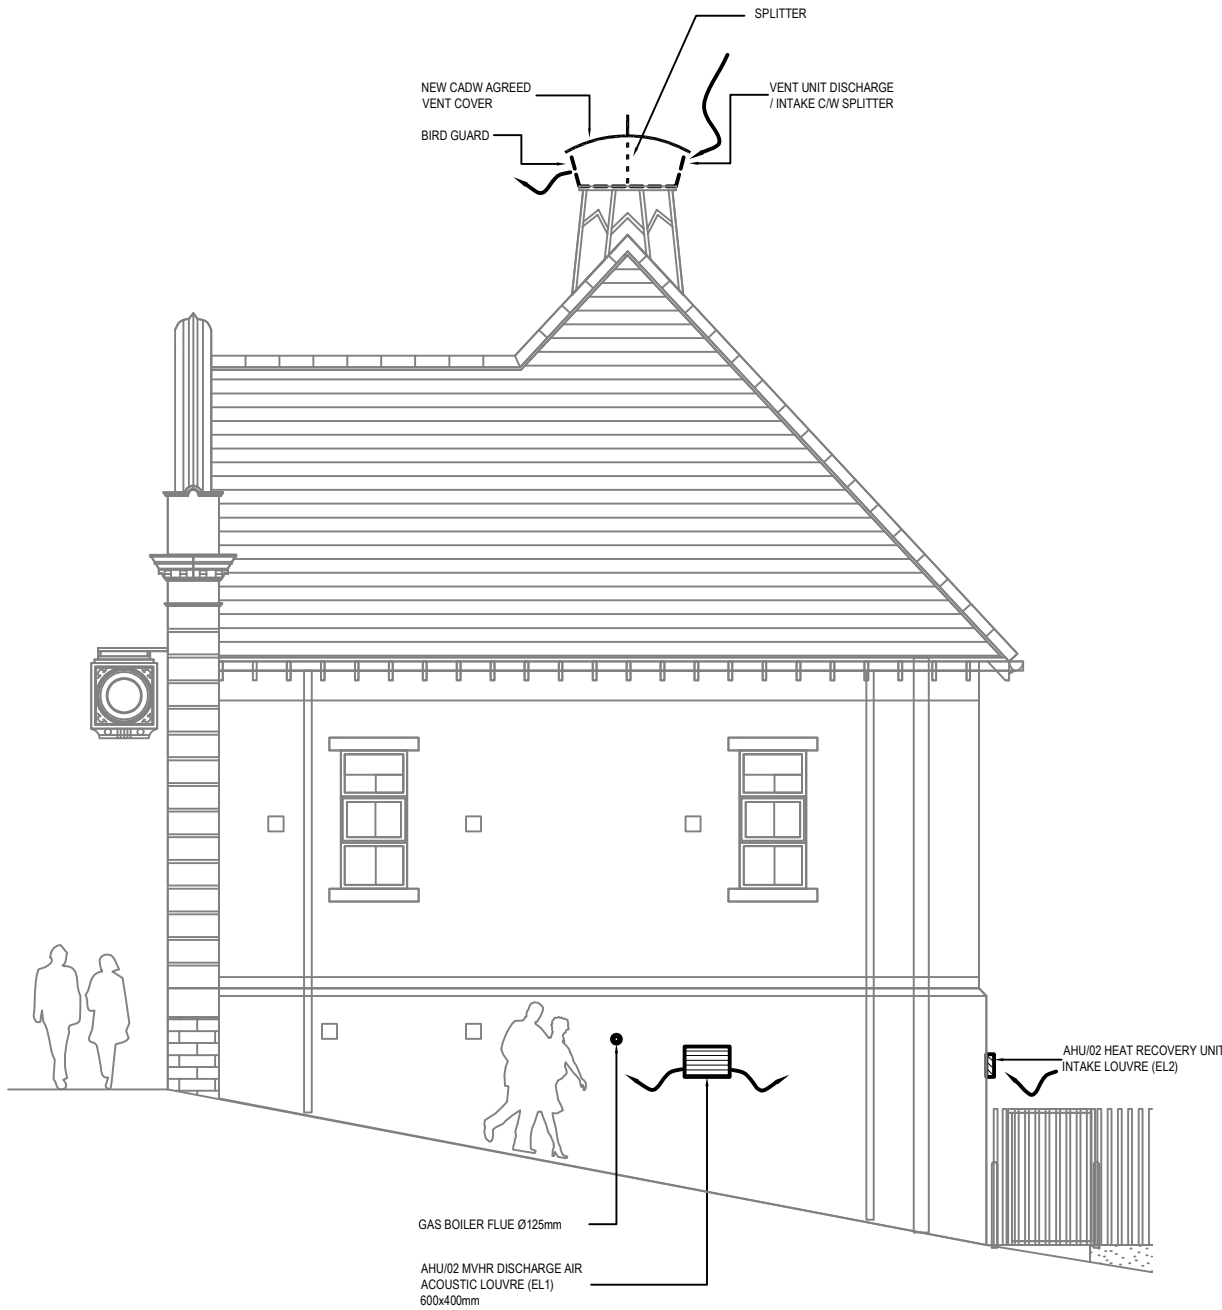

SECTION A-A  
SCALE 1:50

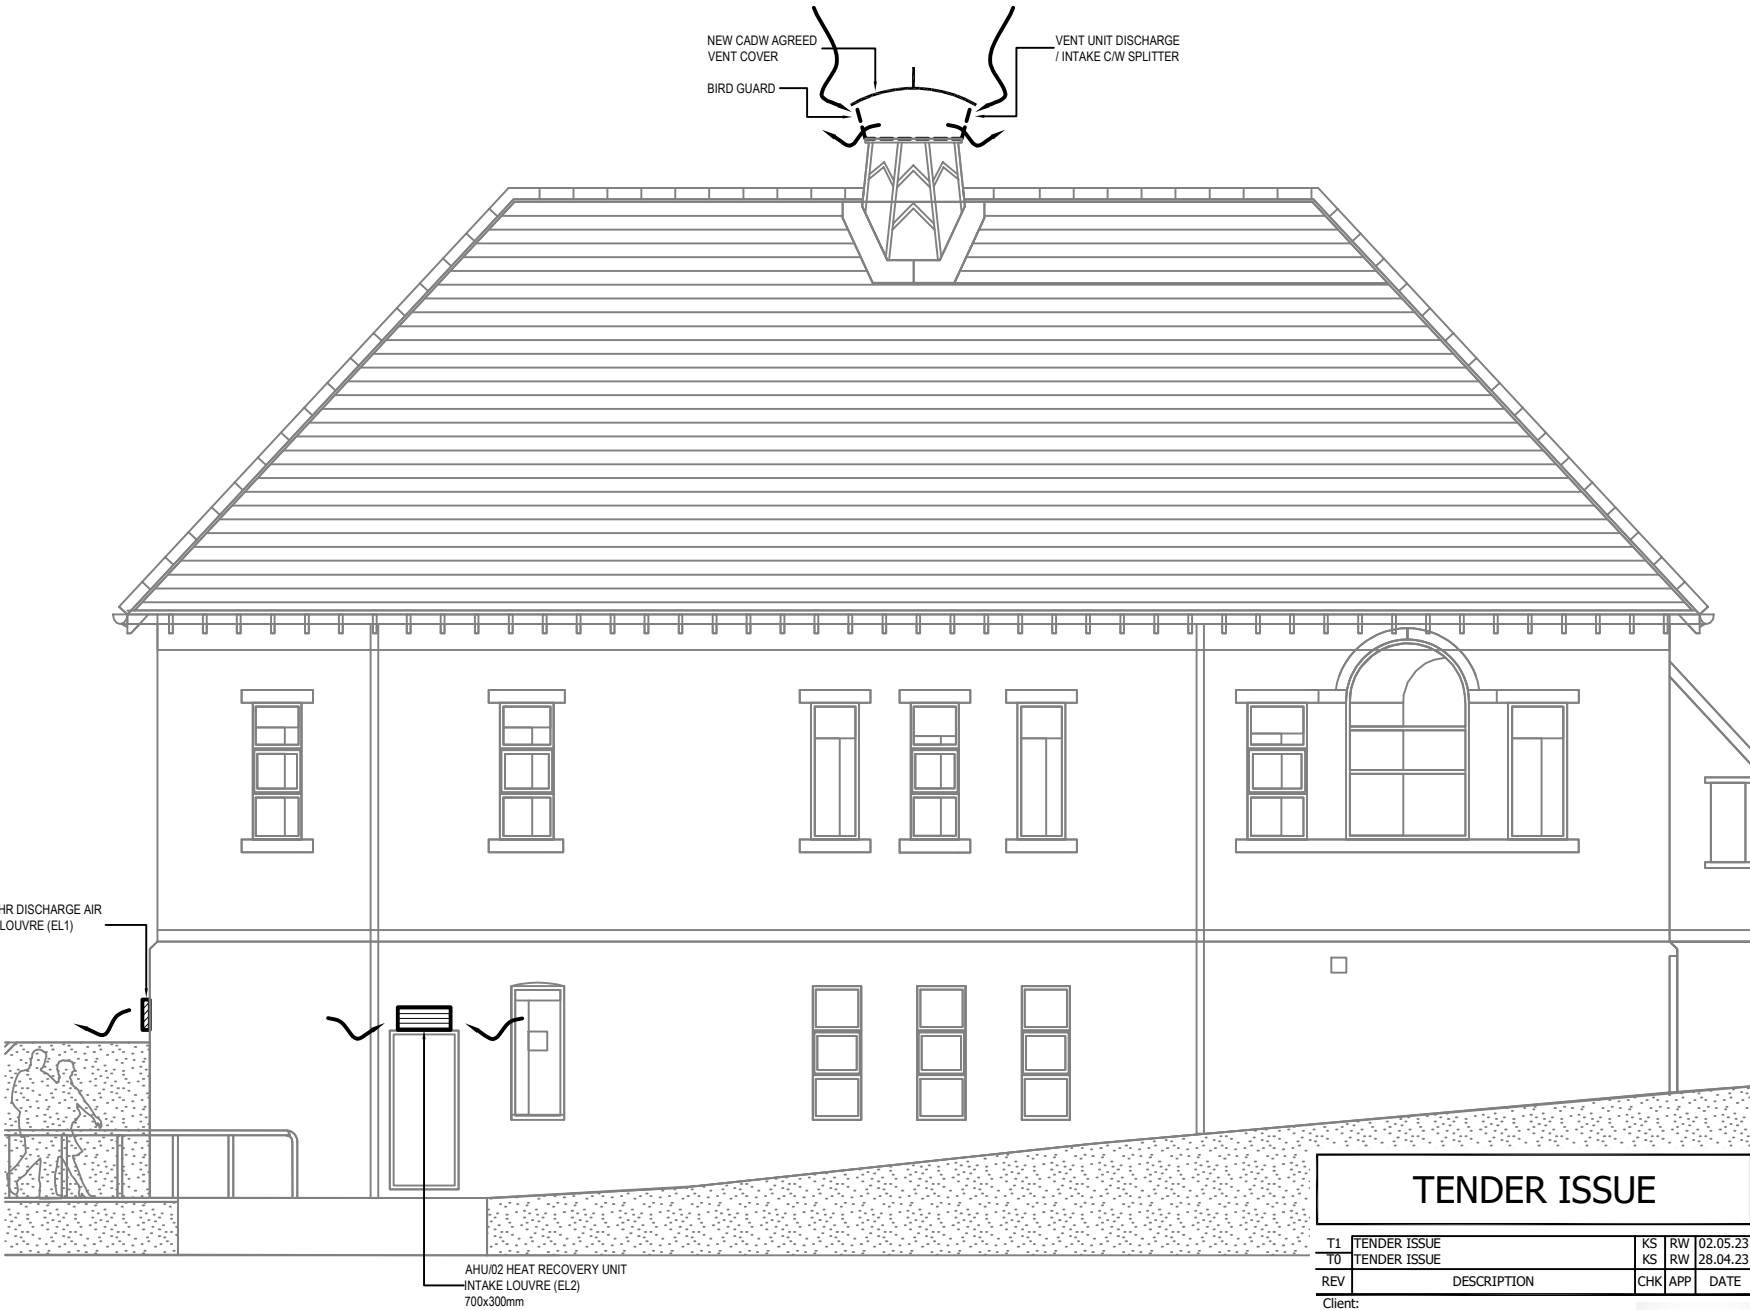

REAR ELEVATION  
SCALE 1:50

TENDER ISSUE

|     |              |     |     |          |
|-----|--------------|-----|-----|----------|
| T1  | TENDER ISSUE | KS  | RW  | 02.05.23 |
| T0  | TENDER ISSUE | KS  | RW  | 28.04.23 |
| REV | DESCRIPTION  | CHK | APP | DATE     |

Client:  
MERTHYR TYDFIL COUNTY BOROUGH COUNCIL  
CIVIC CENTRE, CASTLE STREET,  
MERTHYR TYDFIL, CF47 8AN



4 Ty Nant Court,  
Morganstown,  
Cardiff,  
CF15 8LW  
T: 02920 811266  
F: 02920 814459  
W: [www.draconsulting.com](http://www.draconsulting.com)



Project:  
TREHARRIS LIBRARY

Drawing Title:  
PROPOSED VENTILATION  
ELEVATIONS & SECTIONS  
(SHEET 2 OF 2)

|                 |              |               |                 |                  |                  |
|-----------------|--------------|---------------|-----------------|------------------|------------------|
| Scale @<br>1:50 | A1           | Drawn<br>M.P. | Checked<br>K.S. | Approved<br>R.W. | Date<br>28.04.23 |
| Drawing No.     | DR-1302-M-05 |               |                 |                  | Revision<br>T1   |