
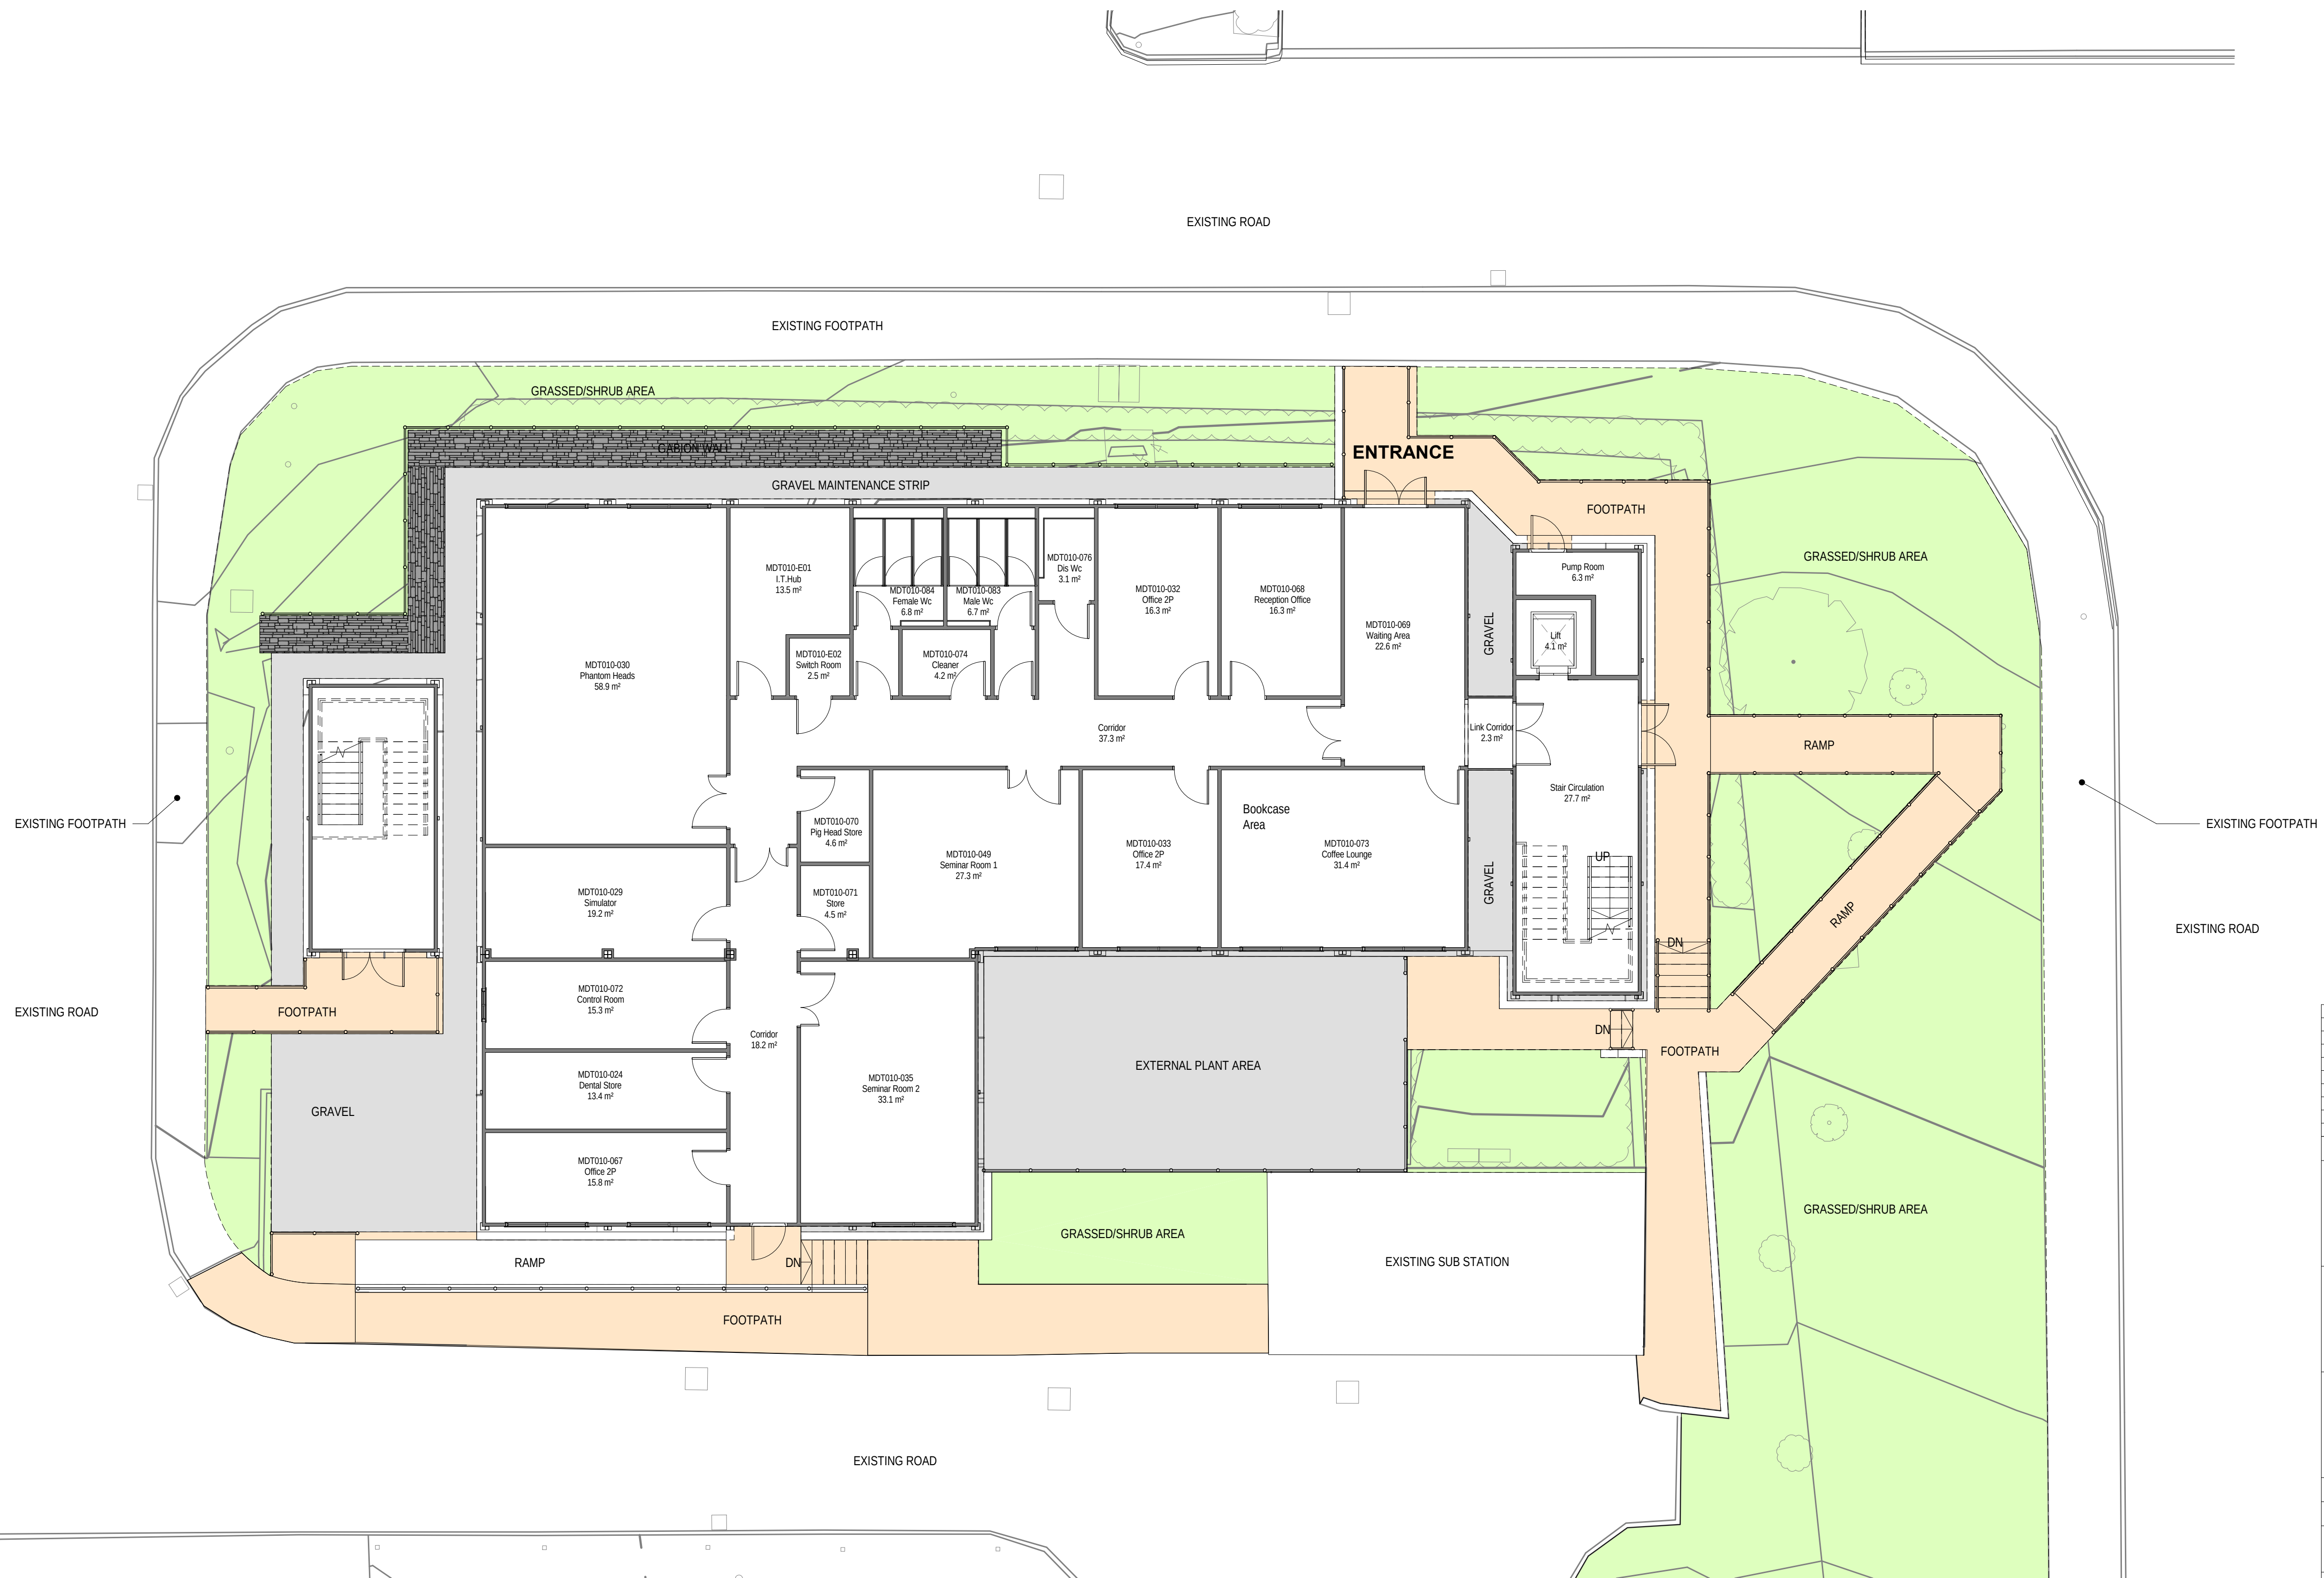


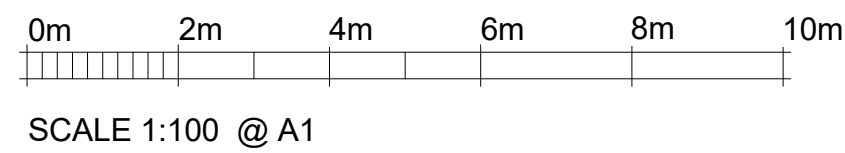

01 - UNIT 3 Portakabin - Planning Issue - Proposed Ground Floor Plan
Scale: 1 : 100

2	13/06/2019	Issued for Planning	CJF
1	10/06/2019	Prepared for Planning - Issued for Comment	CJF
Mark	Date	Details	By

Trust:

	Bwrdd Iechyd Cwm Taf Health Board	CWM TAF HEALTH BOARD Prince Charles Hospital Merthyr Tydfil Mid Glamorgan CF47 9DT
---	--	---

Supply Chain Partner:

 **Interserve**

INTERSERVE CONSTRUCTION
LIMITED
138 HEOL-Y-GORS
CWMBWRLA
SWANSEA
SA5 8LT

Project Title:
Prince Charles Hospital Refurbishment
Merthyr Tydfil
Mid Glamorgan
CF47 9DT

Scale: 1 : 100 for the original size of A1

Drawn By:	CJF	Checked By:	MD	Passed By:	LG	Date:	22/05/19
-----------	-----	-------------	----	------------	----	-------	----------

Drawing Status:

Planning Issue

Drawing Originator:

Boyes Rees Architects
4th Floor, Greyfriars House
Greyfriars Road, Cardiff CF10 3AL
Tel: 029 2055 8900 Fax: 029 2039 9592
www.boyesrees.co.uk
Registered office: As above Reg No.
295 1663 (England & Wales)

Drawing Title:

Unit 3- Proposed Temporary Portakabin -
Ground Floor Plans

Job No:	Drawing No:							Revision:
5005	Project	Origin	Volume	Level	Type	Discip.	Number	
	P003	BRA	V05	00	DR	A	010501	2

Do NOT scale this drawing Refer to Architects for details of current building layouts	Phase:	Workstream:
	■	■