
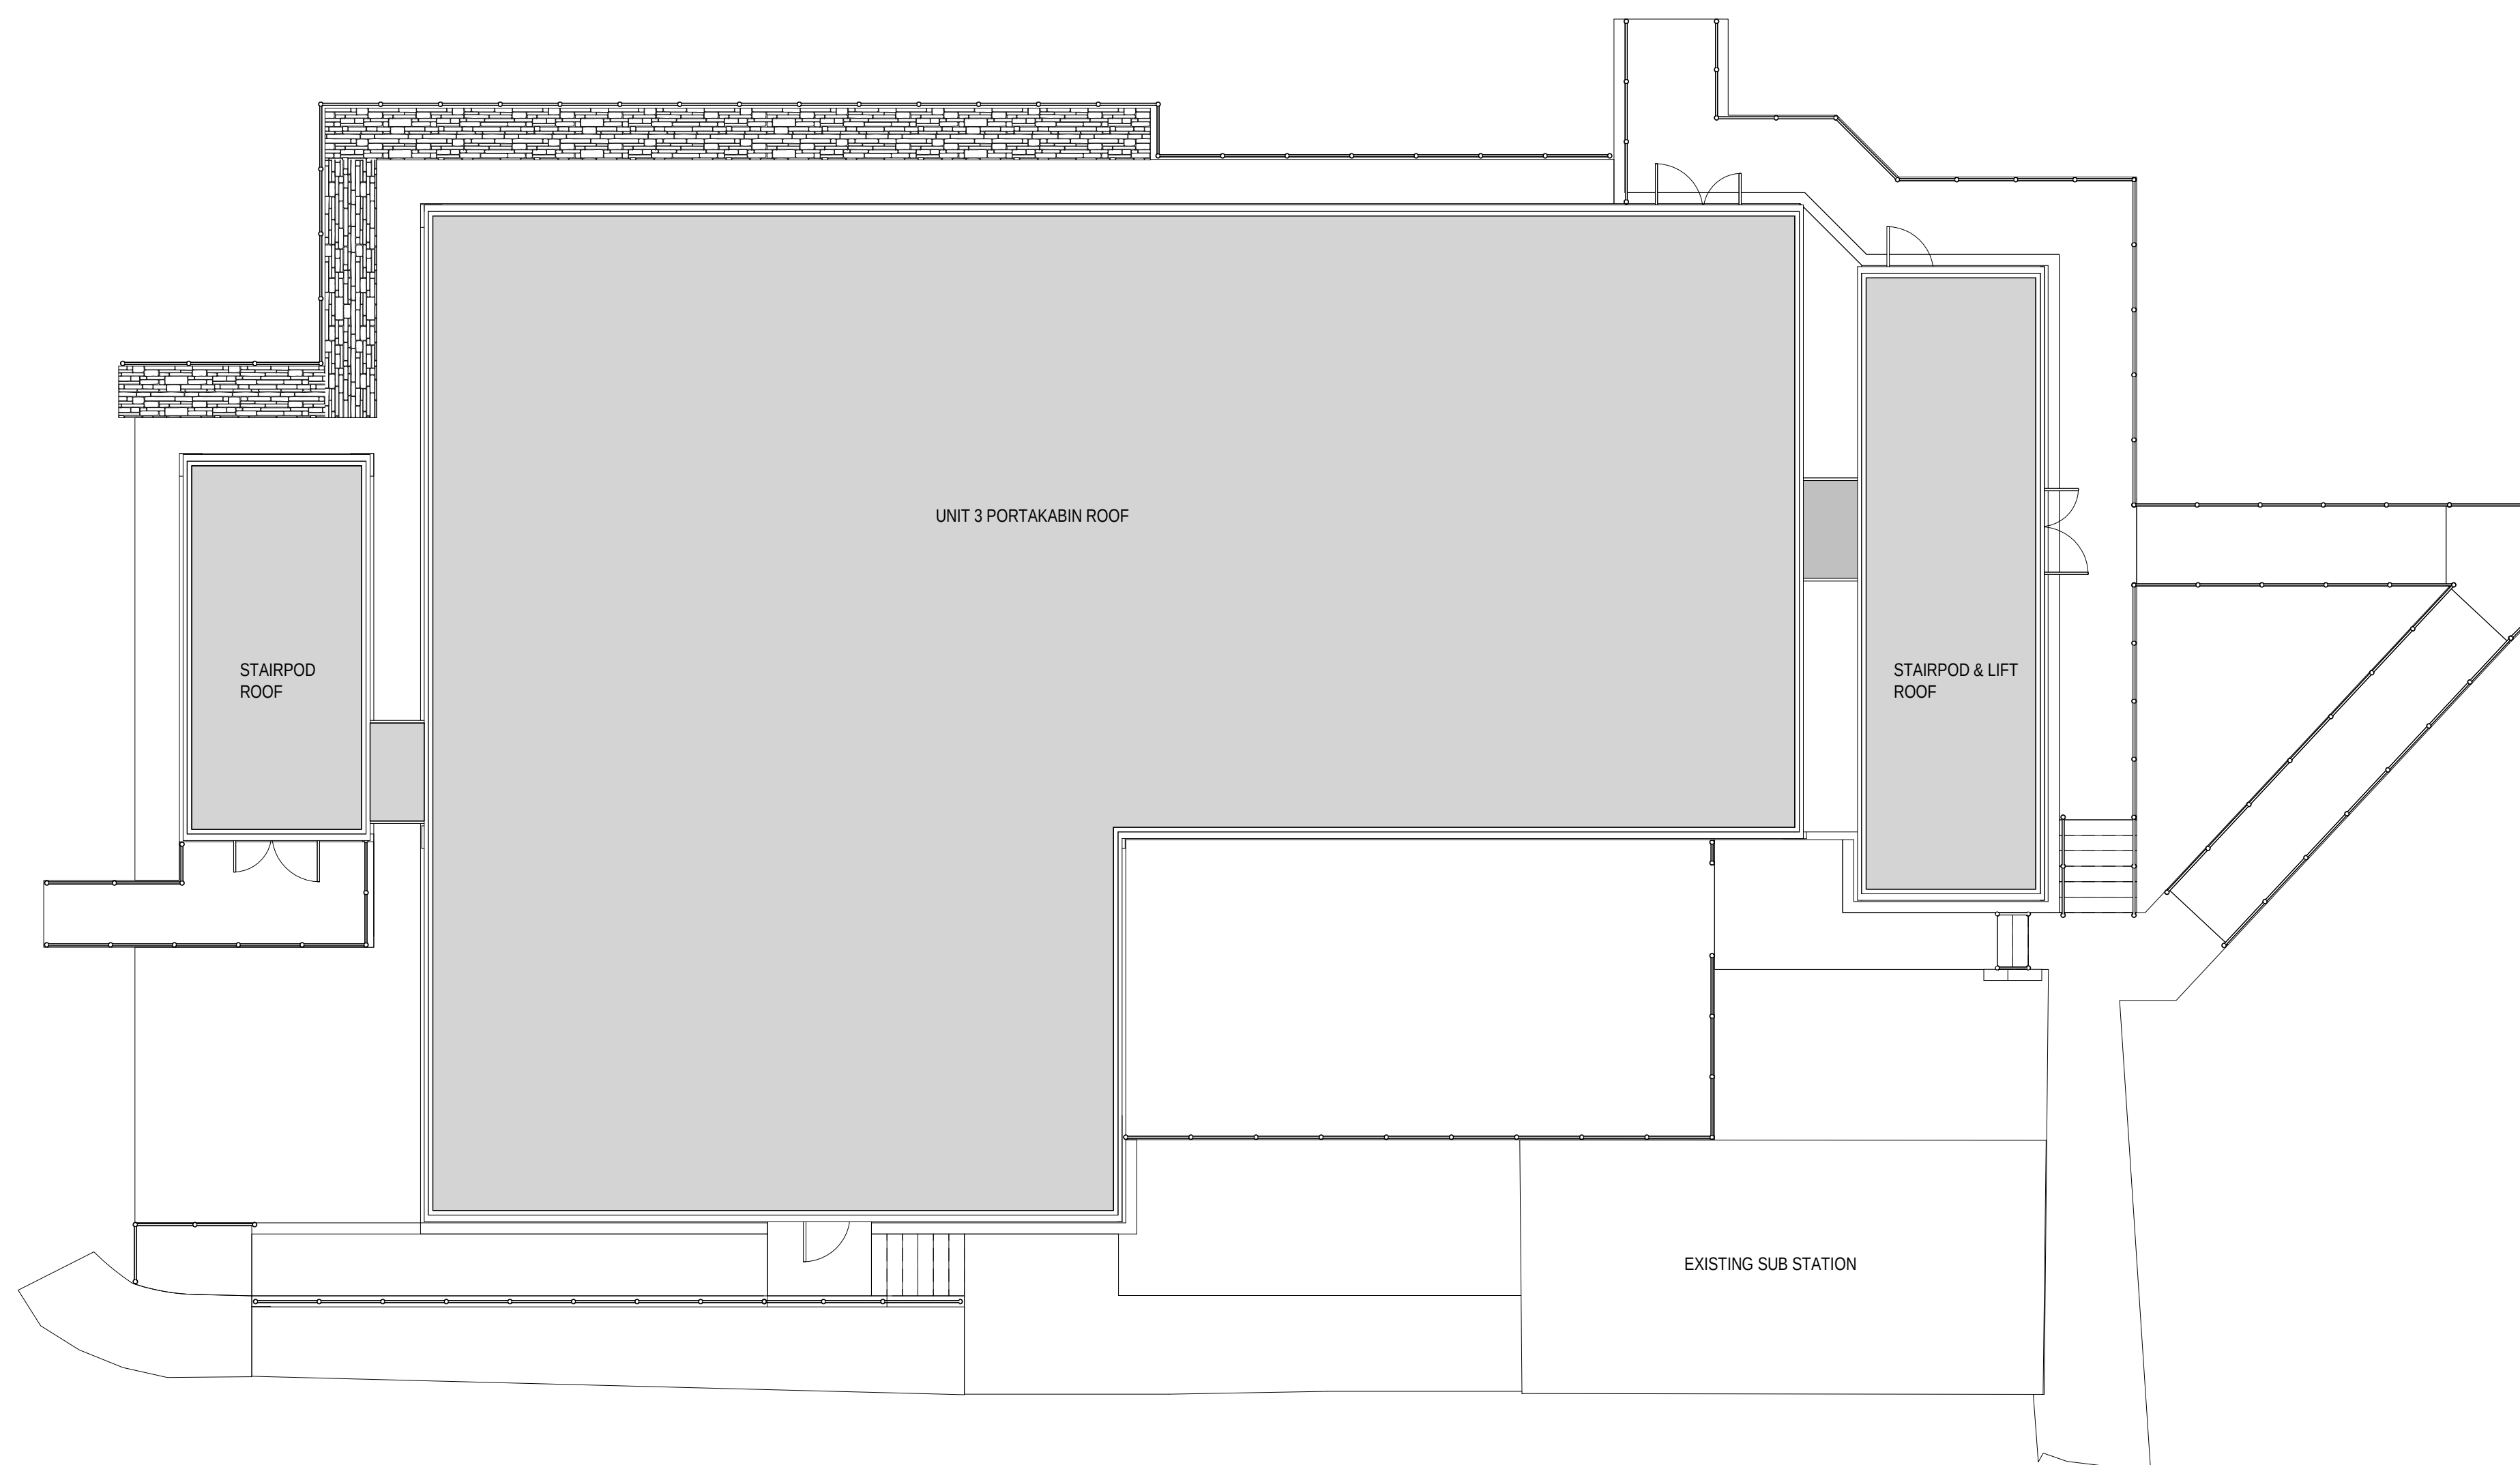


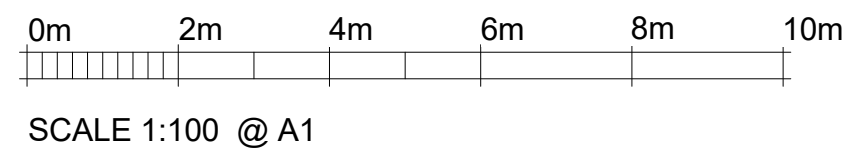

Unit 3 Portakabin - Proposed Roof Plan
Scale: 1 : 100

2	13/06/2019	Issued for Planning							C
1	10/06/2019	Prepared for Planning - Issued for Comment							F
Mark	Date	Details							
REVISIONS									
Trust:									
			Bored techyd Cwm Taf Health Board		CWM TAF HEALTH BOARD Prince Charles Hospital Merthyr Tydfil Mid Glamorgan CF47 9DT				
Supply Chain Partner:									
			INTERSERVE CONSTRUCTION LIMITED 136 HEOL-Y-GORS CWMBWRLA SWANSEA SA5 8LT						
Project Title: Prince Charles Hospital Refurbishment Merthyr Tydfil Mid Glamorgan CF47 9DT									
Scale: 1 : 100 for the original size of A									
Drawn By: C.J.F		Checked By: MD		Passed By: LG		Date: 28/05/			
Drawing Status:									
Planning Issue									
Drawing Originator:			 Boyes Rees Architects 4th Floor, Greyfriars House Greyfriars Road, Cardiff CF10 3AL Tel: 029 2055 8900 Fax: 029 2039 9592 www.boyesrees.co.uk Registered office As above Reg No. 285 1603 (England & Wales)						
Drawing Title: Unit 3 - Proposed Temporary Portakabin - Roof Plan									
Job No:	Drawing No:	Project / Origin:	Volume:	Level :	Type	Discip.	A Number	Revision:	
5005	P003	BRA	V05		DR	A	010503	2	
Do NOT scale this drawing Refer to Architects for details of current building layouts								Phase:	Workstage: