


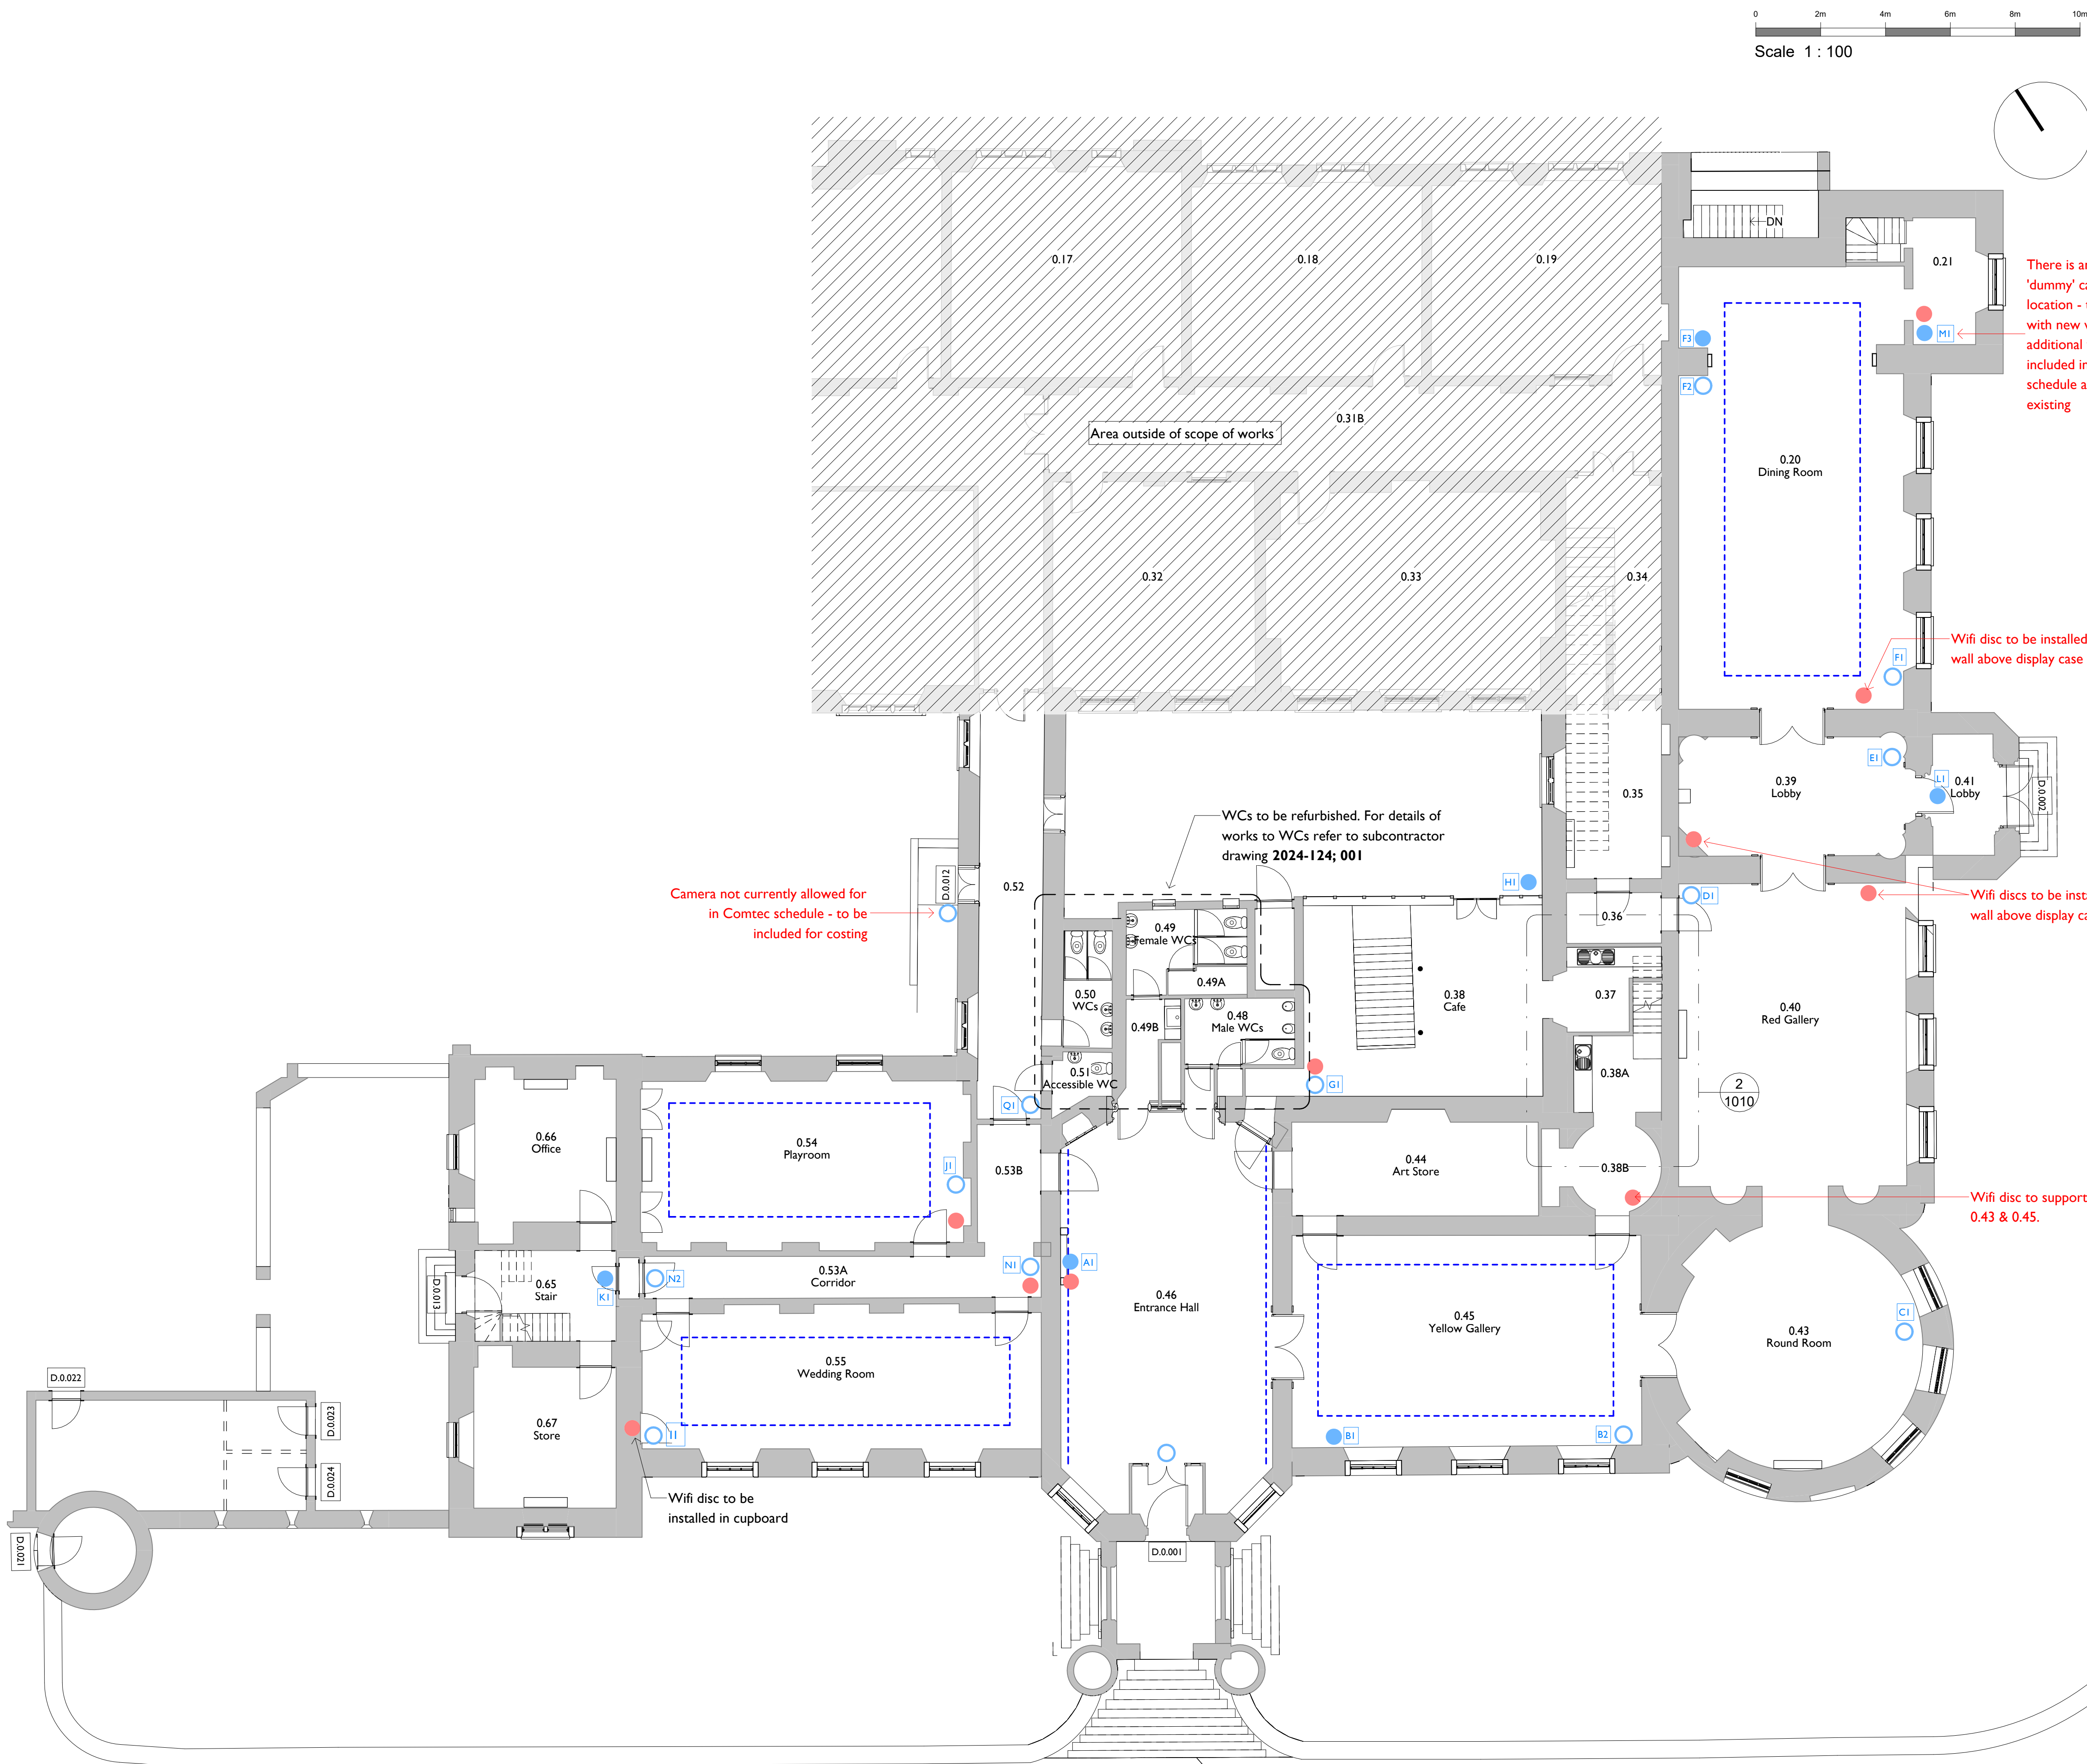

Proposed Ground Floor Plan - Internal Works
1 : 100


Notes:

Drawings are based on survey data and may not accurately represent what is physically present.

Do not scale from this drawing. All dimensions are to be verified on site before proceeding with the work.

All dimensions are in millimeters unless noted otherwise.

Purcell shall be notified in writing of any discrepancies.

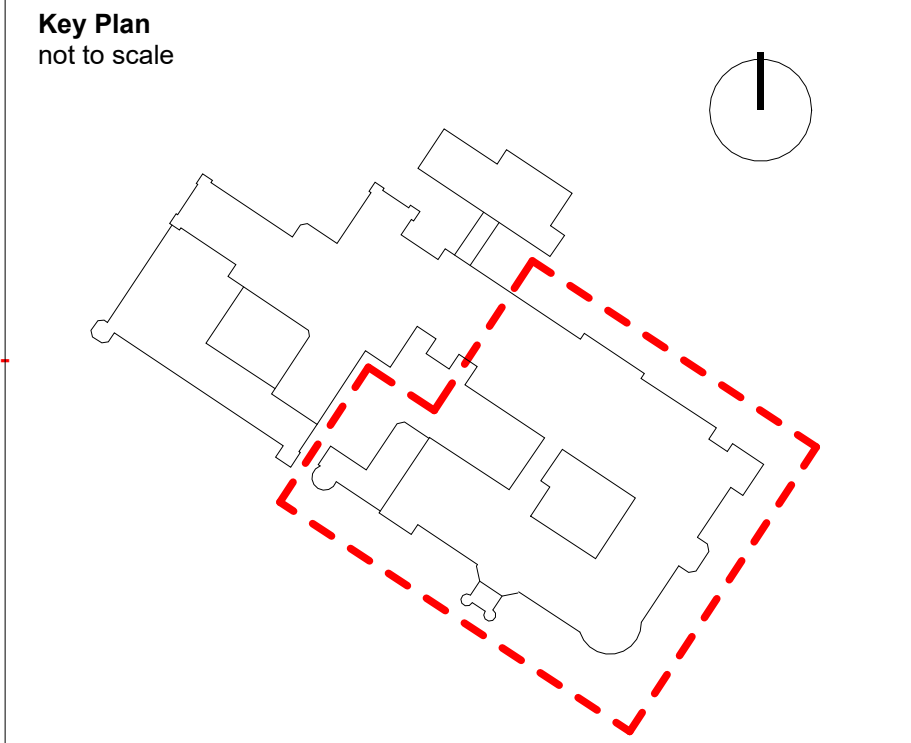

- CCTV New - to replace existing camera
 - CCTV New camera and cabling
 - Call Point New
 - Wifi Disc New
 - Location reference number - relates to Comtec schedule
- APs and CCTV cameras all to be installed at high level. Call points to be installed on wall at accessible height.
- All cabling to be renewed.
- Wifi locations to be reviewed by Comtec and final locations approved by architect on site prior to installation.
- Refer to Comtec info for precise locations and access statement for installation methodology. Final routes of camouflaging of micro trunking to be agreed on site with architect.
- Lighting tracks in existing location (indicatively shown with dashed line) to be renewed in line with Tamlite Lighting proposals
 - Existing cable tray location (overhead) indicated with dashed line. Indicative only - precise location not surveyed.

REV	DATE	BY	CHK	DESCRIPTION
CLIENT				
Merthyr Tydfil County Borough Council				
PROJECT				
Cyfarthfa Castle Roof Works				
JOB NUMBER				
241638				
TITLE				
Proposed Ground Floor Plan - Internal Works				
SIZE SCALE				
A1L 1 : 100				
REV SUITABILITY/REASON FOR ISSUE				
T1 - For Tender				
DRAWING NUMBER				
CCRW-PUR-01-00-DR-A-0200				
PURCELL® IS THE REGISTERED TRADE NAME FOR PURCELL ARCHITECTURE LTD AND ALL SUBSIDIARY COMPANIES AND IS REGISTERED IN THE UNITED KINGDOM, EUROPEAN UNION, HONG KONG, CHINA AND AUSTRALIA. © PURCELL 2024. www.purcelluk.com				