


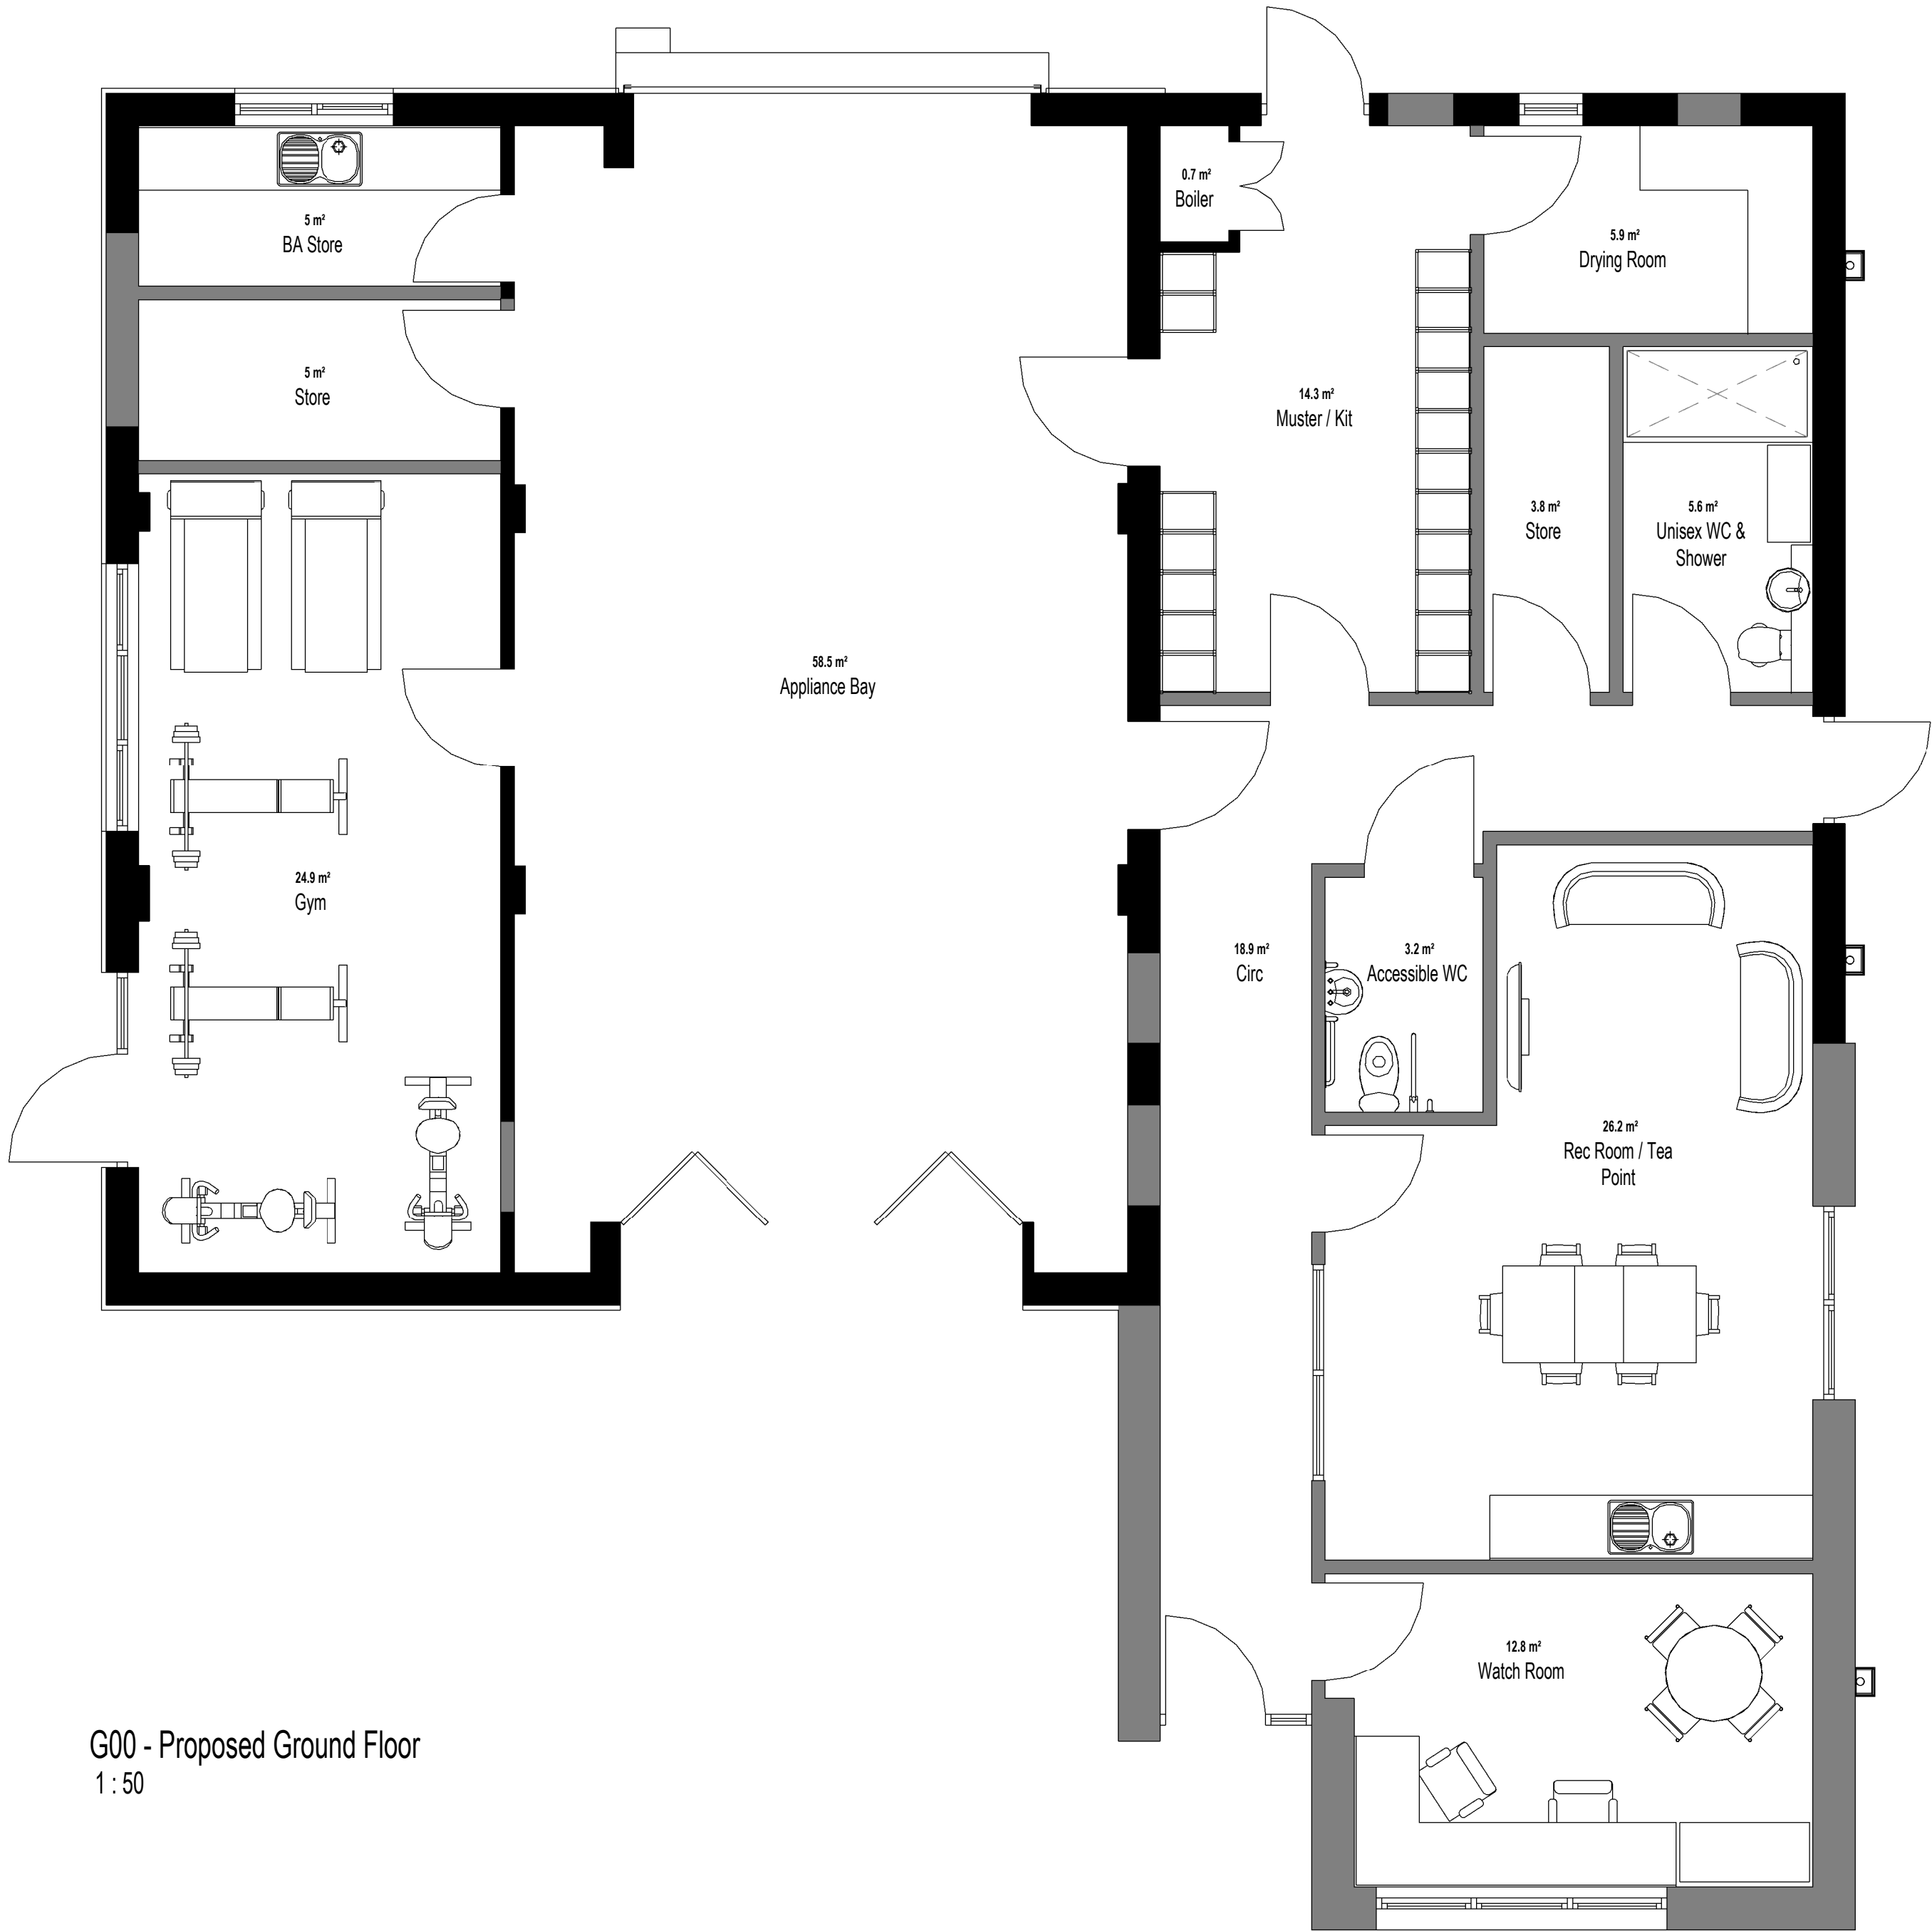

G00 - Proposed Ground Floor
1 : 50

P00 - Issued for Planning HD HD KJ	07/07/2022
REV DESCRIPTION DRAWN BY CHECKED BY APPROVED BY	DATE
RIBA PLAN OF WORK 2013 WORKSTAGE	LEVEL OF MODEL DEFINITION (LoD)
Stage 3 - Developed Design	LoD 3 - Approximate Model
PURPOSE OF ISSUE - SUITABLE FOR ...	BS1192 STATUS
Planning Submission	Status S3 - Review & Comment

lawrayarchitects
penseiri

CARDIFF
LONDON
WREXHAM
www.lawray.co.uk

029 2052 8140
0207 138 3560
01978 357 887

CLIENT
South Wales Fire & Rescue Service

PROJECT TITLE
Treharris Fire Station

DRAWING TITLE
Proposed Ground Floor Plan

PROJECT No 19413	SCALE @ A2 1 : 50
DRAWING No (BS1192:2007 +A2:2016) & BS EN ISO19650	PROJECT - ORIGINATOR - VOLUME - LEVEL - TYPE - ROLE - NUMBER TH-LAW-X-G00-DR
REVISION A-061001	P00
DO NOT SCALE Any discrepancy or query concerning this drawing should be referred to the Architect Copyright © LAWRAY LIMITED Registered Office: Greenmeadow Springs, 1 Cae Gwyrdd, Tongwynlais, CARDIFF CF15 7AB Reg. Co. No. 2724178, VAT Reg. No. 134 2146 06	