


FILENAME : E:\PROJECTS\DR-1302 TREHARRIS LIBRARY AND CAEDRAW EXTENSION\02 CAD\MEP\MECHANICAL\NEW\DR-1302-M-07 (T1) PROPOSED ROOF LEVEL HEATING LAYOUT.DWG | PLOTTED BY : MATT PHILLIPS | PLOTTED DATE : 02 May 2023 12:29:47

- NOTES :
- DO NOT SCALE: CONTRACTOR TO CHECK ALL DIMENSIONS AND REPORT ANY OMISSIONS OR ERRORS
 - ALL DIMENSIONS ARE IN MILLIMETRES, UNLESS NOTED OTHERWISE
 - THIS DRAWING IS NOT FOR INSTALLATION PURPOSES. DESIGN, INSTALLATION AND CO-ORDINATION DRAWINGS SHALL BE PROVIDED BY THE CONTRACTOR IN ACCORDANCE WITH THE SPECIFICATION. THE CONTRACTOR IS TO READ THIS DRAWING IN CONJUNCTION WITH THE HEALTH AND SAFETY PLAN AND DESIGN HAZARD INFORMATION.

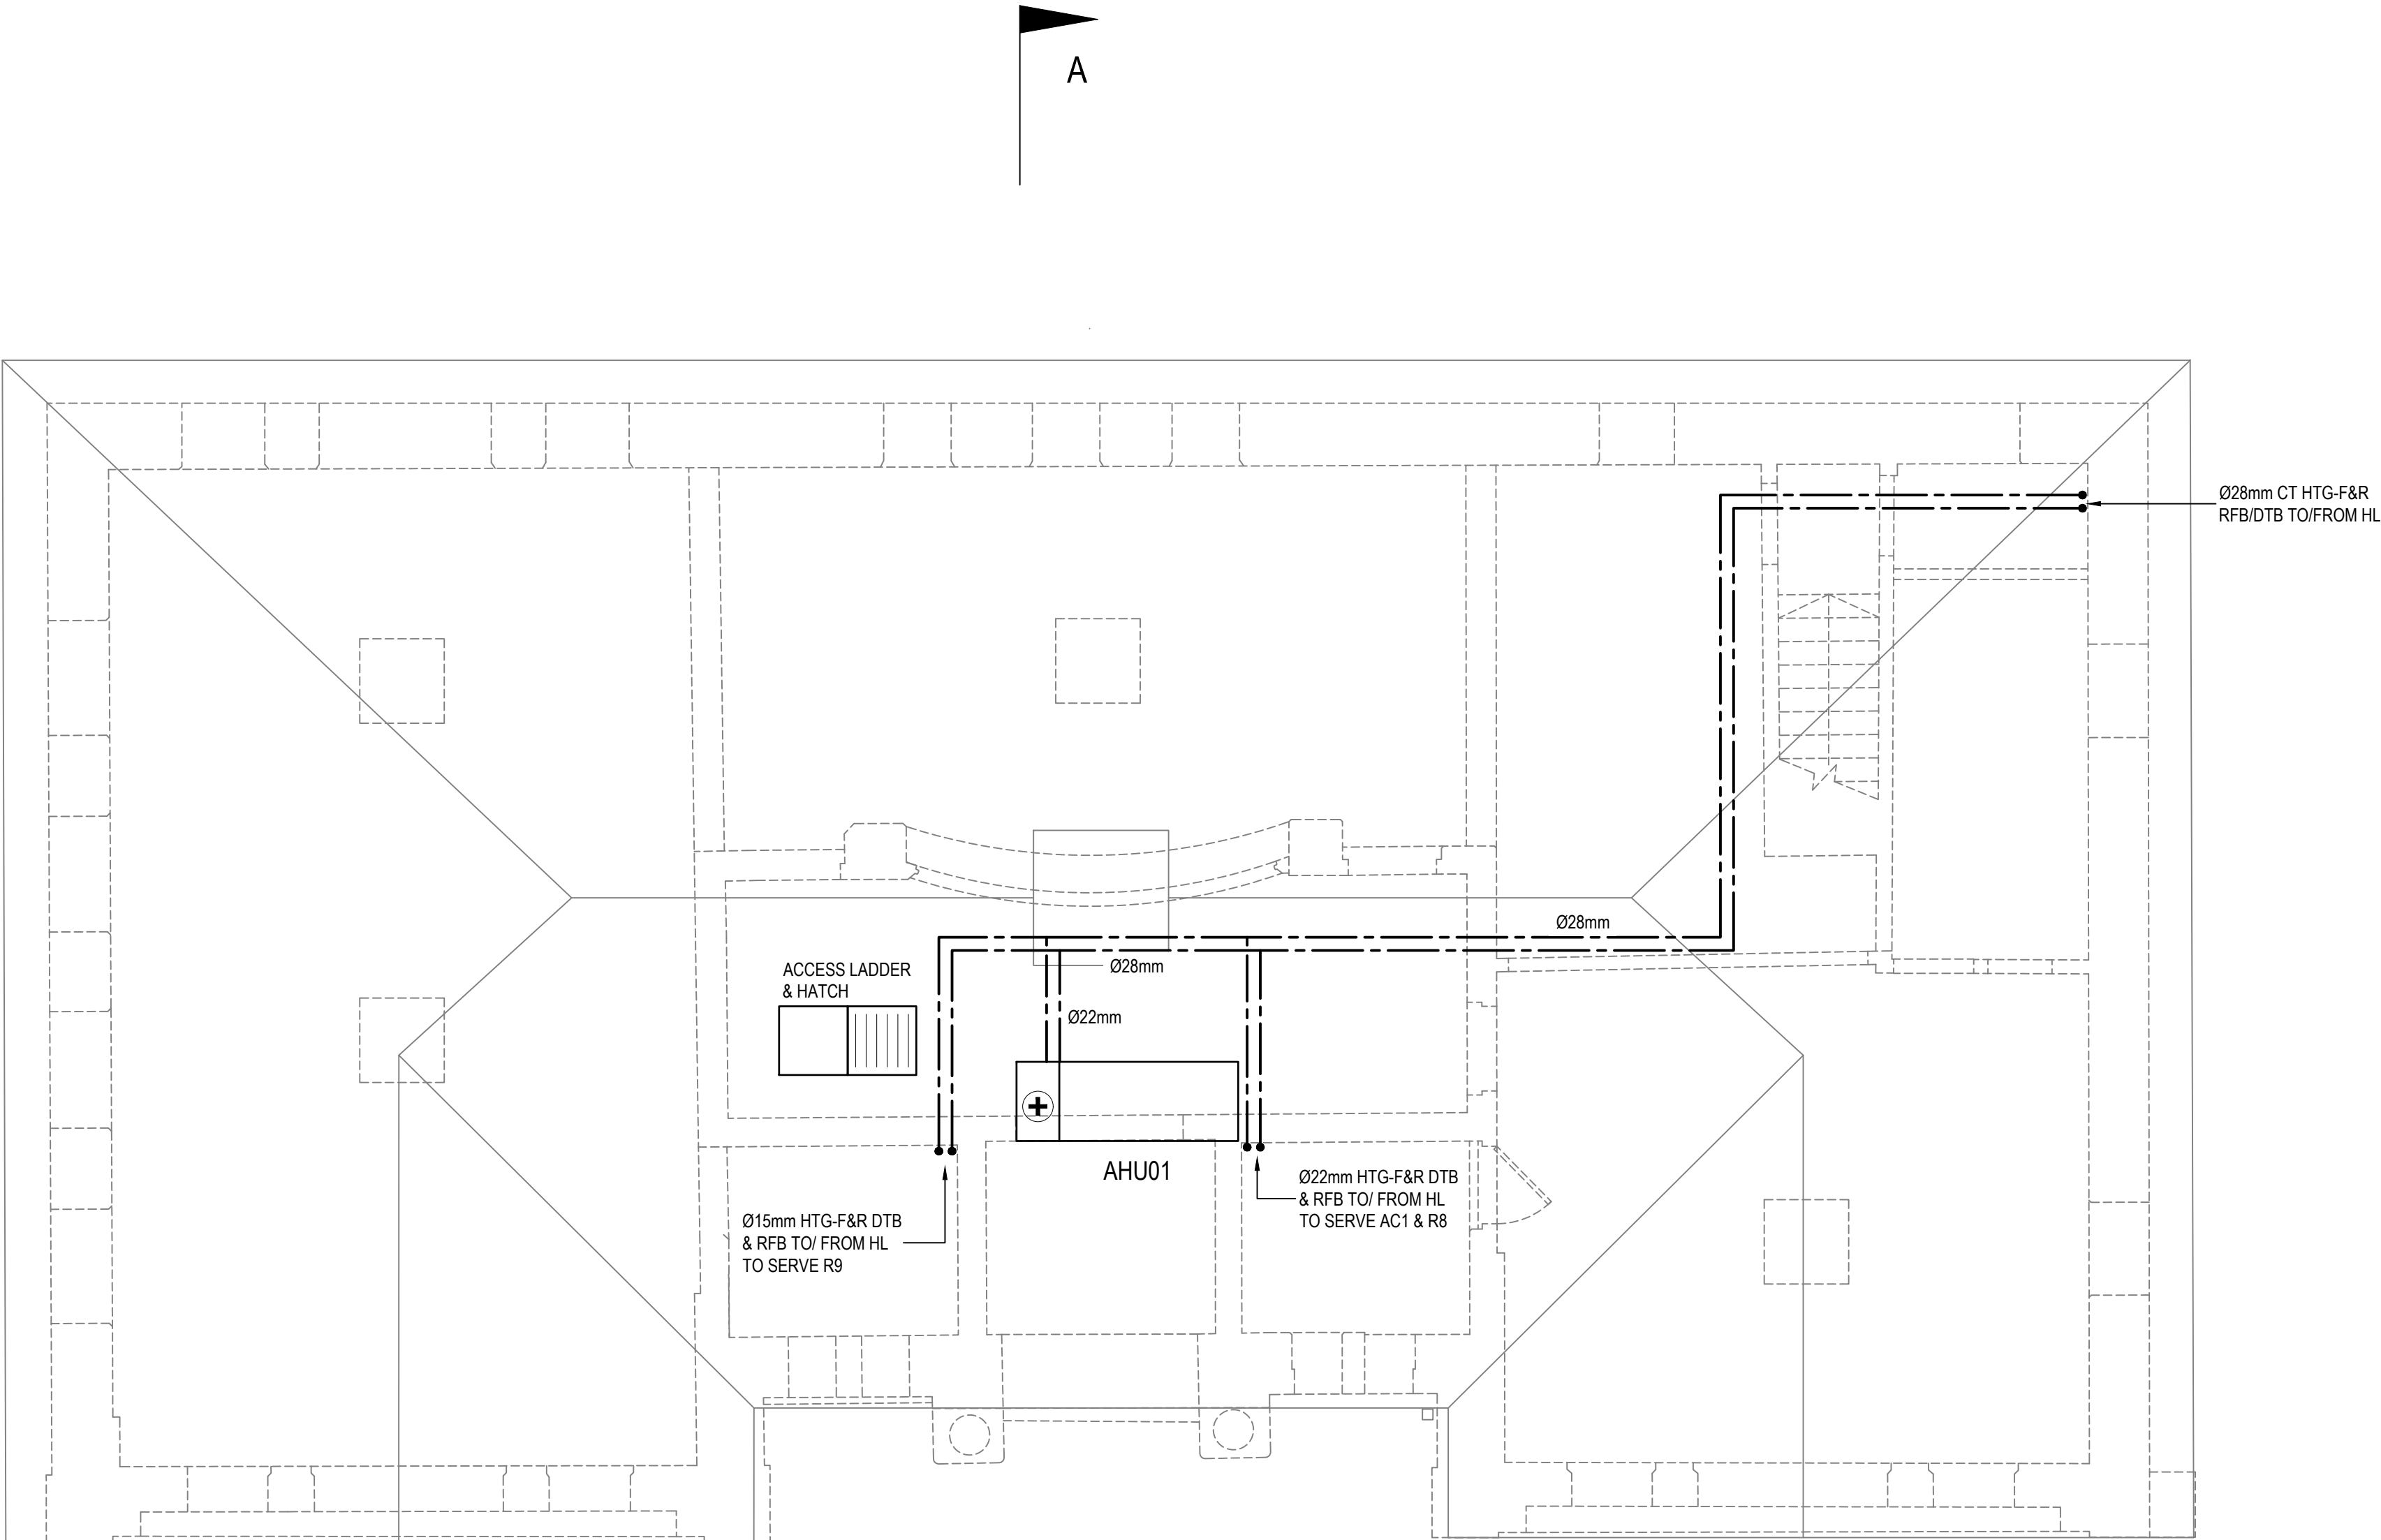

ROOF LEVEL
SCALE 1:50

0 500 1000 1500 2000 2500mm
SCALE 1:50 @ A1; 1:100 @ A3

TENDER ISSUE

T1	TENDER ISSUE	KS	RW	02.05.23
T0	TENDER ISSUE	KS	RW	28.04.23
REV	DESCRIPTION	CHK	APP	DATE

Client:

MERTHYR TYDFIL COUNTY BOROUGH COUNCIL
CIVIC CENTRE, CASTLE STREET,
MERTHYR TYDFIL, CF47 8AN



4 Ty Nant Court,
Morganstown,
Cardiff,
CF15 8LW



T: 02920 811266
F: 02920 814459
W: www.dracconsulting.com

Project:
TREHARRIS LIBRARY

Drawing Title:
PROPOSED ROOF LEVEL
HEATING LAYOUT

Scale @ A1 1:50	Drawn M.P.	Checked K.S.	Approved R.W.	Date 28.04.23
Drawing No.	DR-1302-M-07			Revision T1