



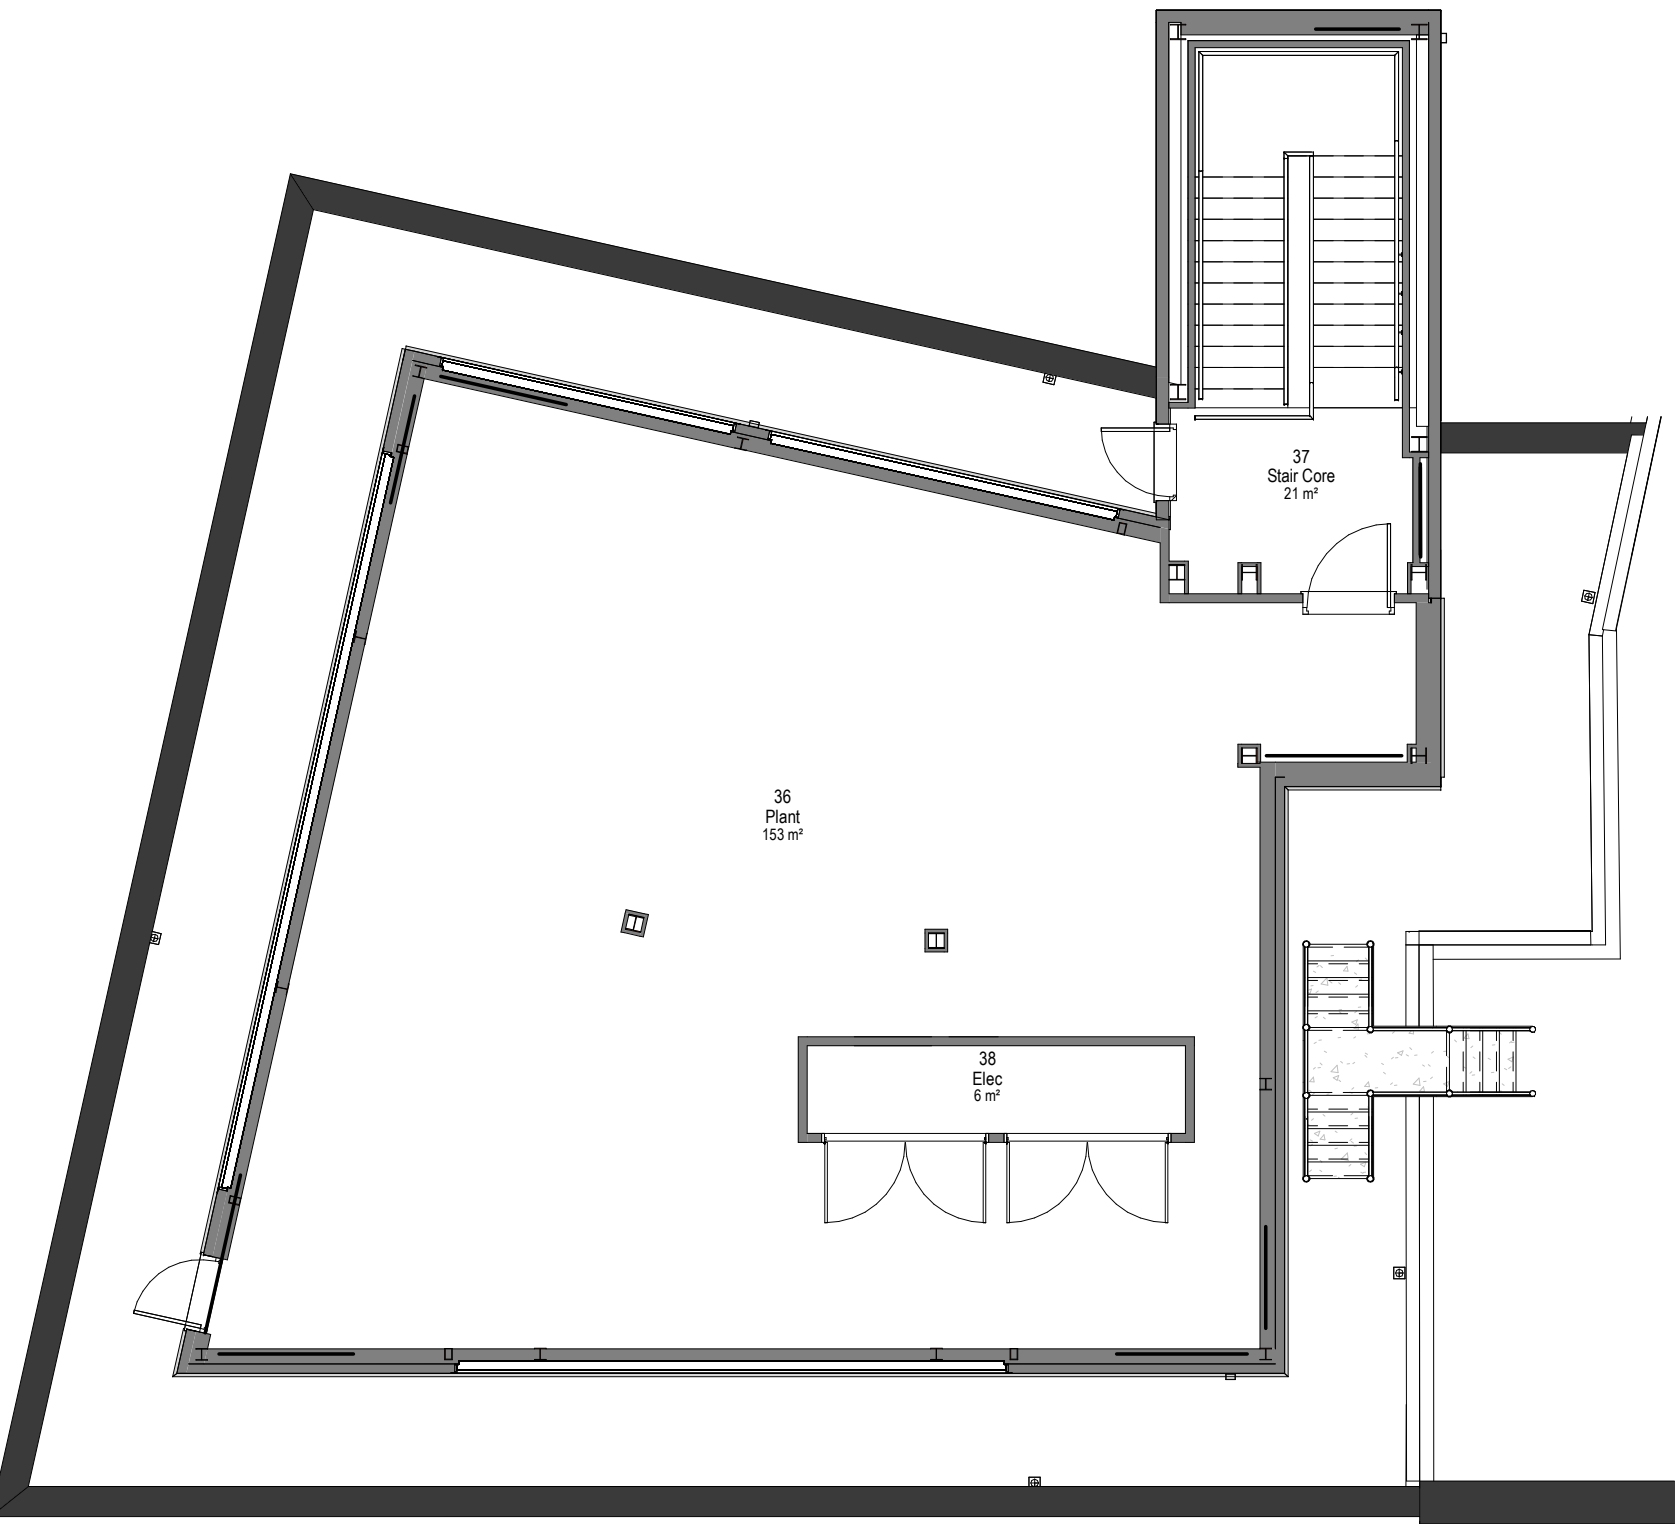

Mark	Date	Details	By
P05	26/02/2021	Issued For Planning	AC
P04	17/02/2021	Issued for comment Pre-Full Planning	KD
P03	06/01/2020	North point rotated to suit	WW
P02	16/12/2019	Structural grids have been shown for co-ordination purposes	WW
P01	13/11/2019	Pre-application issue	WW

Trust:

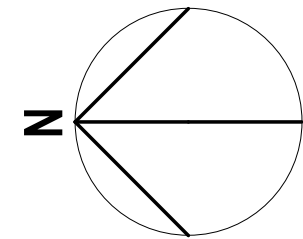

Bwrdd Iechyd Prifysgol
Cwm Taf
University Health Board

CWM TAF MORGANNWG
UNIVERSITY HEALTH BOARD
Prince Charles Hospital
Merthyr Tydfil
Mid Glamorgan
CF47 9DT

Supply Chain Partner:



INTERSERVE CONSTRUCTION LTD
138 HEOL-Y-GORS
CWMBWRLA
SWANSEA
SA5 8LT

Project Title/ Address:
Prince Charles Hospital
Merthyr Tydfil
Mid Glamorgan
CF47 9DT

Scale: 1 : 100 for the original size of A3

Dwn By: WW Chkd By: ML Passed By: MU Date: 26/02/2021

Drawing Status:
PLANNING ISSUE

Drawing Originator:



© HLMArchitects
Suite 104
The Creative Quarter
Morgan Arcade
The Hayes
Cardiff CF10 1AF

www.hlmarchitects.com
T. +44 (0) 29 2039 6070
cardiff@hlmarchitects.com
F. +44 (0) 29 2039 6080

Drawing Title:
Medical Day Unit, Proposed Roof Plan

Job No:	Drawing No:	Project	Origin.	Volume	Level	Type	Discip.	Number	Revision:
5005	P003	HLM	V06	RF	DR	A	0103	P05	
Do NOT scale this drawing Refer to Architects for details of current building layouts								Phase: 2	Section: 1

02 - Proposed Roof Plant Plan
Scale: 1 : 100

