
 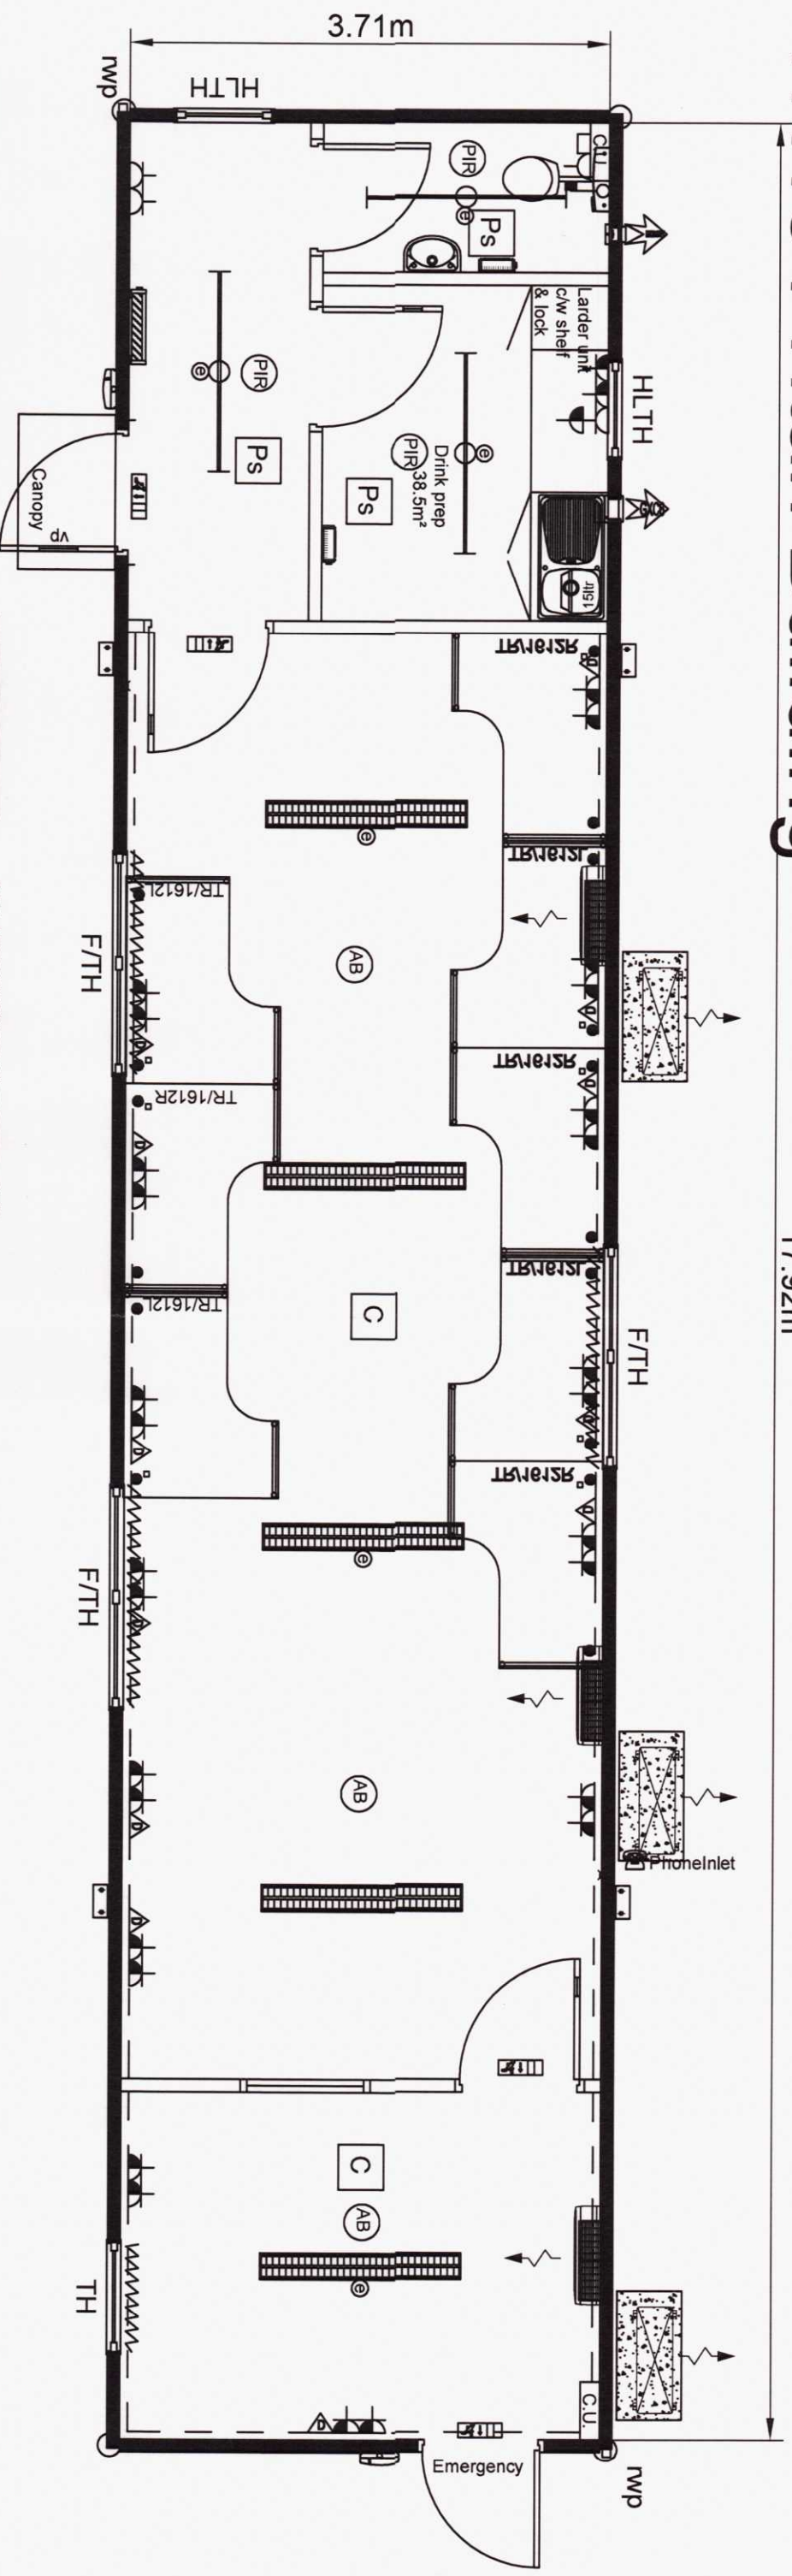


# TN184 Titan Building

17.92m

**Do not scale off this drawing. All discrepancies to be reported to Portakabin Limited.**



| Legend                                                                               |                                                                   |
|--------------------------------------------------------------------------------------|-------------------------------------------------------------------|
|     | Single phase consumer unit                                        |
|     | Switch fused spur                                                 |
|     | 1 gang switched socket                                            |
|     | 2 gang switched socket                                            |
|     | 2 gang switched socket<br>(Mounted above worktop)                 |
|     | 100mm Low wattage extract fan cw time delay                       |
|     | 150mm extract fan                                                 |
|      | 1.5m LED light fitting                                            |
|    | 1.5m LED light fitting with emergency light                       |
|     | 1.5m LED light fitting with emergency light<br>cw diffuser        |
|     | PIR complete with daylight linking                                |
|     | Indicative position split A/C system - Condenser unit (External)  |
|     | Indicative position split A/C system - Evaporator unit (Internal) |
|     | LED Bulkhead light fitting cw emergency light                     |
|     | 3hr, N/M emergency light cw legend                                |
|     | Emergency light key test switch                                   |
|   | 1 gang switched socket, SFS above                                 |
|   | Absence detector. (office)                                        |
|   | Heating controller & spur                                         |
|   | Unvented water heater                                             |
|   | 2KW convector heater                                              |
|   | 3 compartment trunking (CAT 5)                                    |
|   | Venetian Blind                                                    |
|   | H/L fan Heater                                                    |
|  | Data outlet                                                       |
|   | Carpet Tile                                                       |
|   | Polysate Vinyl Floor                                              |

NOTE

1. BUILDING IN GOOSEWING GREY 10A05 WINDOW FRAMES IN ANTHRACITE RAL 7016 DOOR PANEL IN ANTHRACITE RAL 7016 FASCIA IN GREY RAL 7042
2. PLUMBING SERVICES THROUGH THE WALL
3. FIRE ALARM BY OTHERS
4. FURNITURE SHOWN FOR LAYOUT ONLY

Floor Area 66.61 m<sup>2</sup>  
Ceiling Height 2.5 m

## Window Key

Fixed

TH = Top Hung

-LTH = High Level Top Hung

-LLF = High Level Fixed

-TH = Fixed / Top Hung

| Rev | Item                              | Name   | Date     |
|-----|-----------------------------------|--------|----------|
| A   | Larder unit & data outlets added  | R Hyde | 15/11/19 |
| B   | Data outlet added to meeting room | R Hyde | 19/11/19 |



|             |  |           |  |                                      |  |
|-------------|--|-----------|--|--------------------------------------|--|
| Project     |  |           |  | MATERNITY OFFICE                     |  |
| Client      |  |           |  | Interserve Construction Services Ltd |  |
| Title       |  |           |  | Floor Plan                           |  |
| Date        |  | Drawn     |  |                                      |  |
| 30/09/19    |  | LAH       |  |                                      |  |
| Scale       |  | 1:50 @ A3 |  |                                      |  |
| Drg. No.    |  | Rev.      |  | B                                    |  |
| OPP118177 2 |  |           |  |                                      |  |

Portakabin Limited Huntingdon York YO32 9PT  
Telephone 01904 611655 Fax 01904 611644

OPP118177 2 B