


Ysgol Rhyd y Grug Proposed Building Layout

Symbol	Quantity	Article number	Article name
	13	OPUB L30 BL C827	B1
	12	OPUWP L15 AS C727	W1
	10	AME2 NM3 LE3	A1

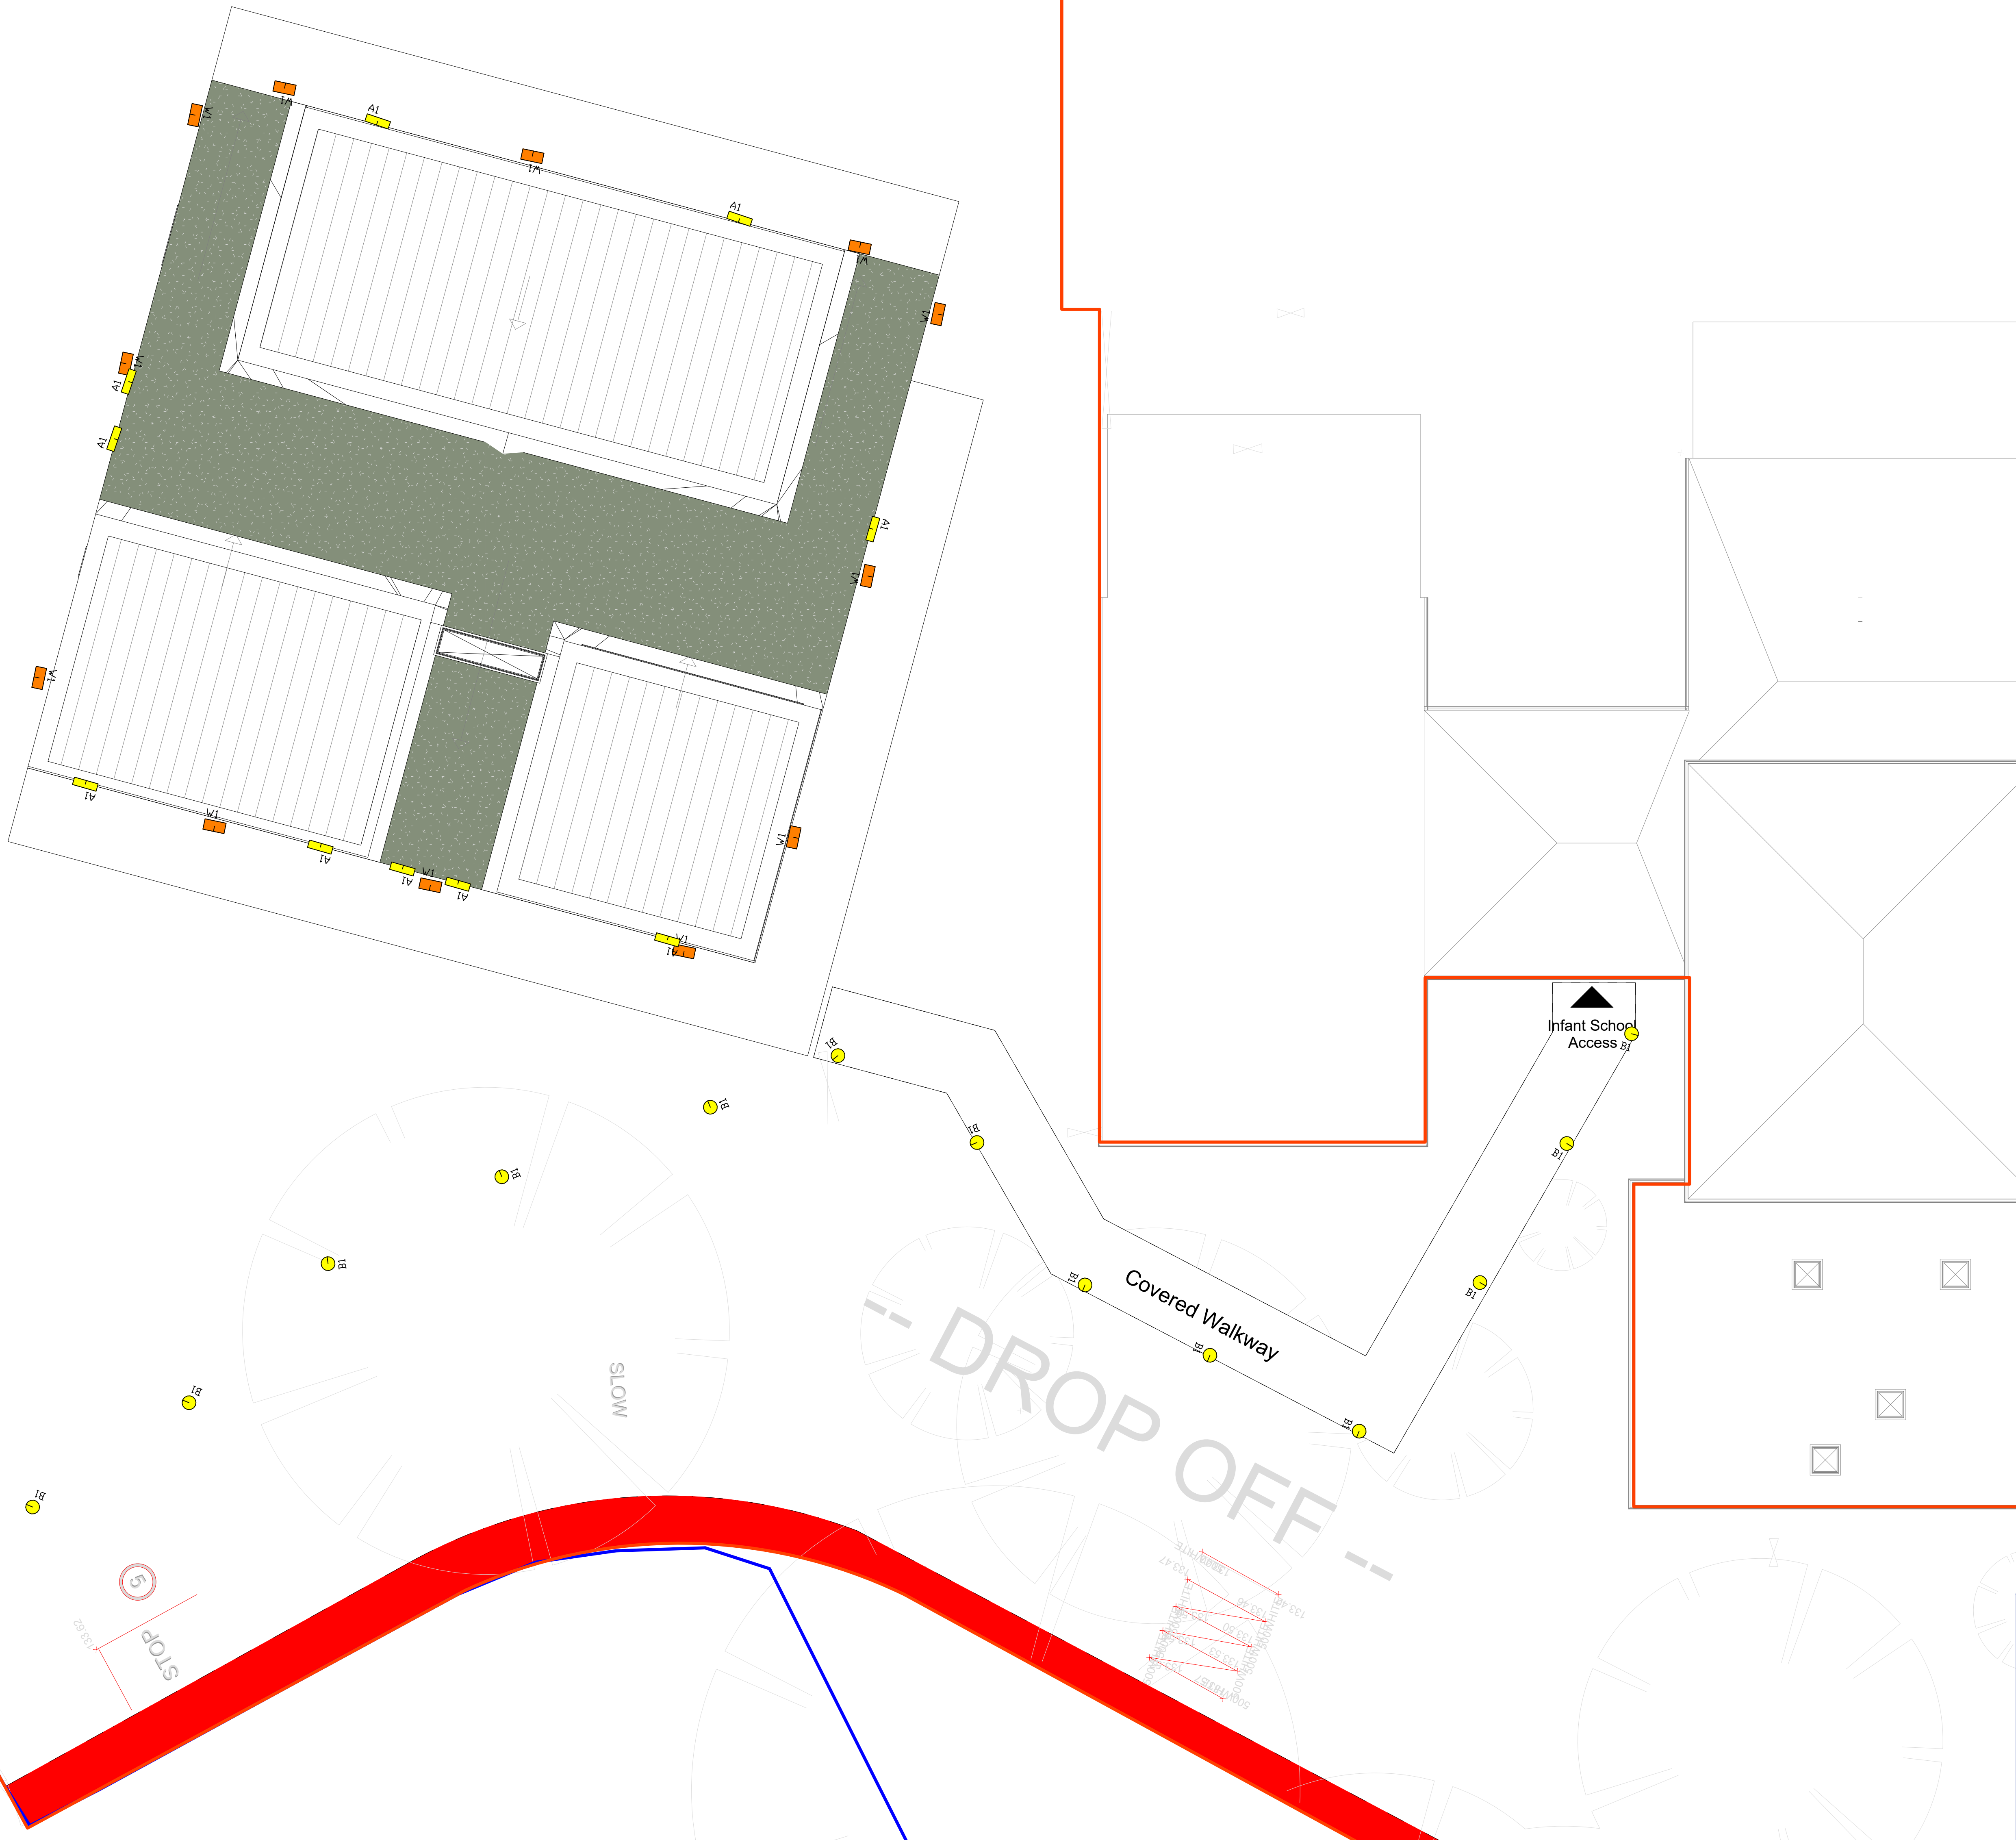

Lighting design layout has been performed according to current standards, information supplied prior to commencing design and good design practice.
Onsite conditions, reflectance values, unknown obstructions, performance of specific components and assumptions made by Engineers may cause differences between calculated and measured and delivered values.
Dextra Group PLC will NOT accept any responsibility for the indicative emergency layout.
This drawing is for indicative purposes and Dextra Group PLC will NOT be held responsible for any decisions in either design or specific onsite complications.
PDF conversions to CAD drawings may not be dimensionally accurate.

Scheme No: 654449
Project: Ysgol Rhyd y Grug
Description: External Lighting Design Layout
File Name: 05449 - Ysgol Rhyd y Grug - Proposed Building - Lighting Layout
Customer: ---
Rev: B
Dwn: GT
Checked: JT
Date: 31/03/2025
Scale: 1:100
A0

NOTES:

Dextra
GROUP PLC
Dextra Group PLC | Bromwich Business Park, Olmgrove, Donast. B96 4PX
T: 01747 688100 | F: 01747 688106 | E: lighting@dextragroup.co.uk